



Operations and Maintenance Facility South

Draft Environmental Impact Statement Appendix C: Conceptual Design Plans




SOUND TRANSIT - LINK LIGHT RAIL



CONCEPTUAL ENGINEERING PLANS

OPERATIONS AND MAINTENANCE FACILITY SOUTH
(OMF SOUTH)

MARCH 2021

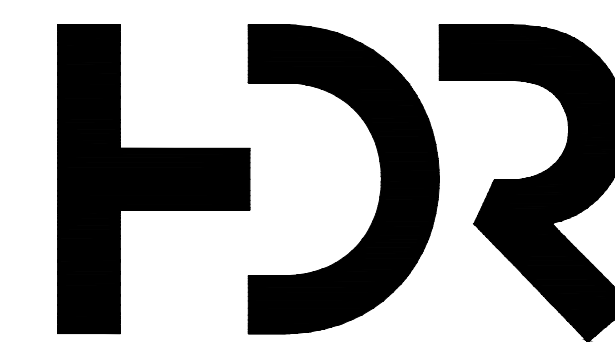


***SOUND TRANSIT
OPERATIONS AND MAINTENANCE FACILITY SOUTH***

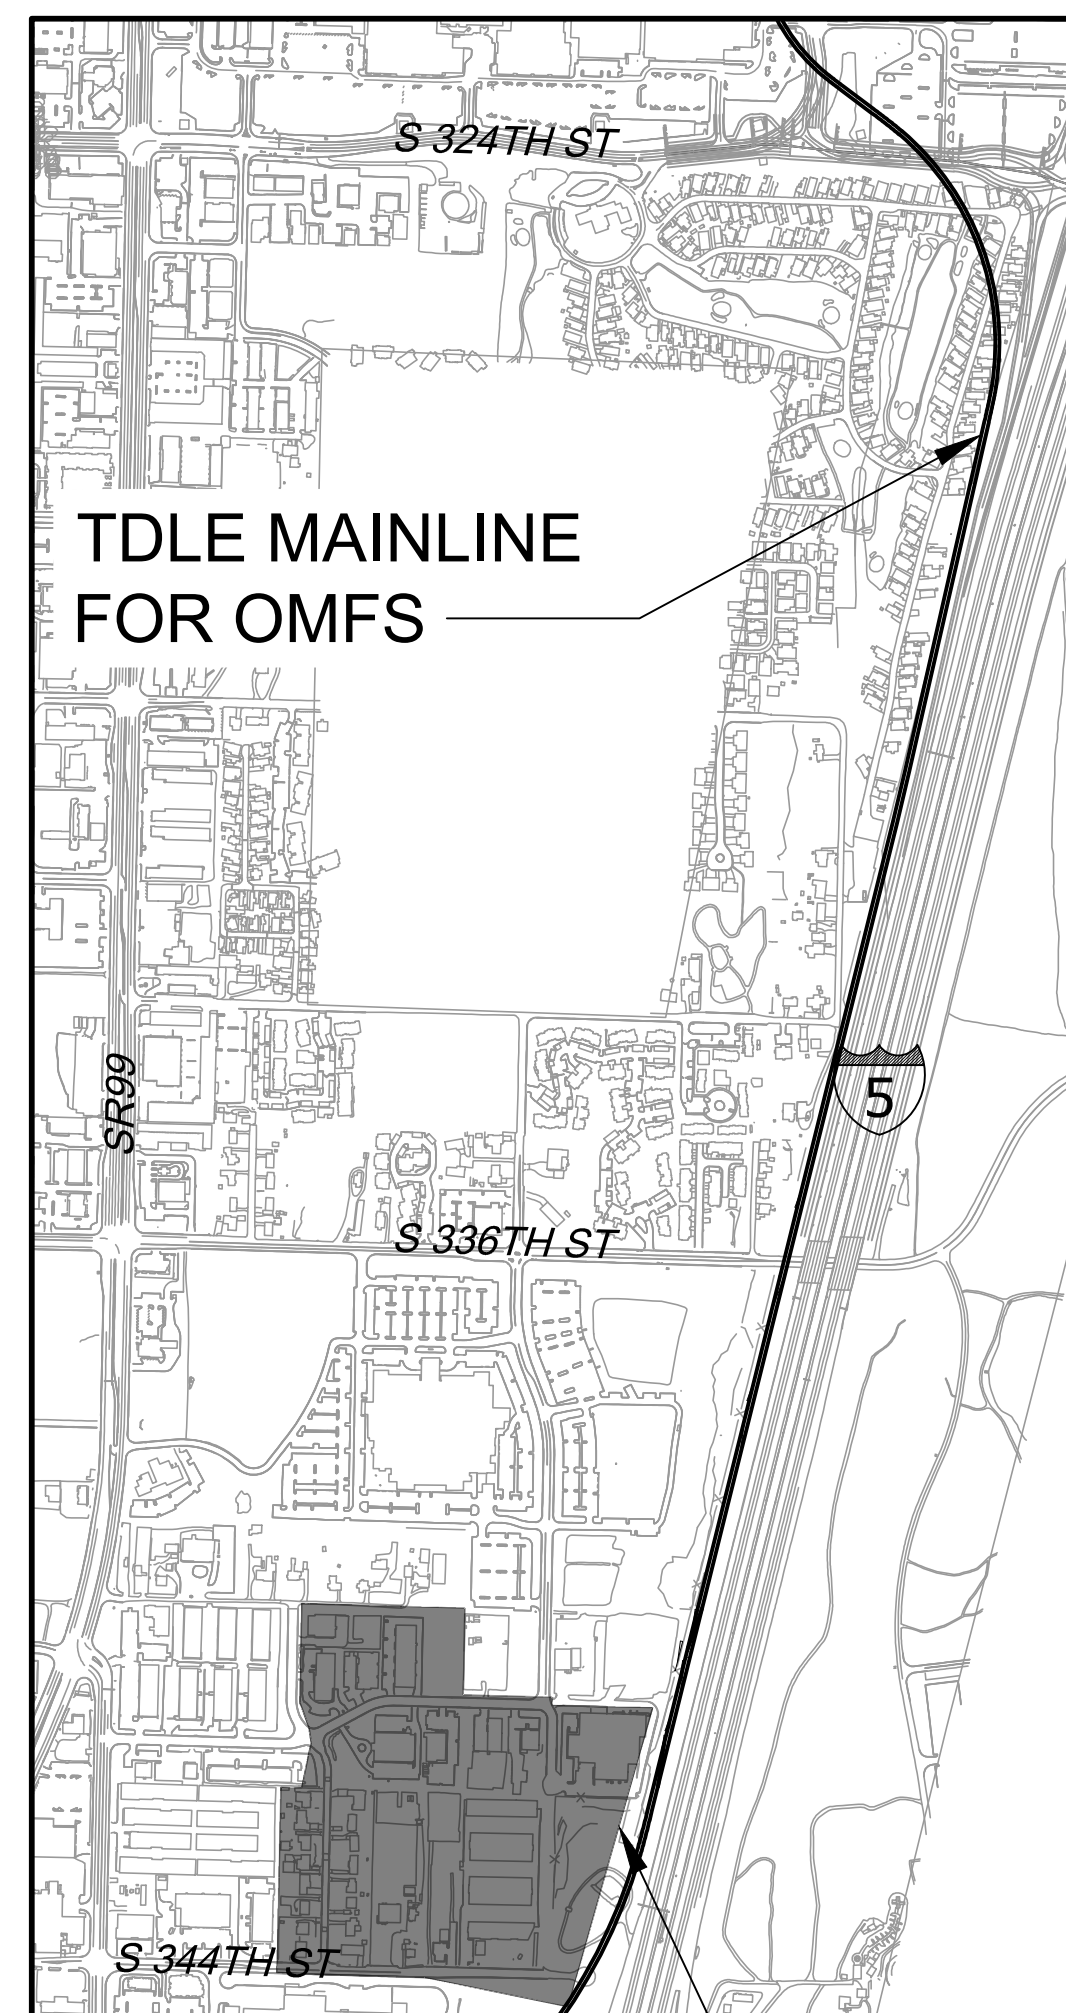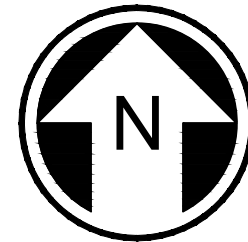


TDLE MAINLINE FOR OMFS

PROJECT LOCATION
S 344TH ST

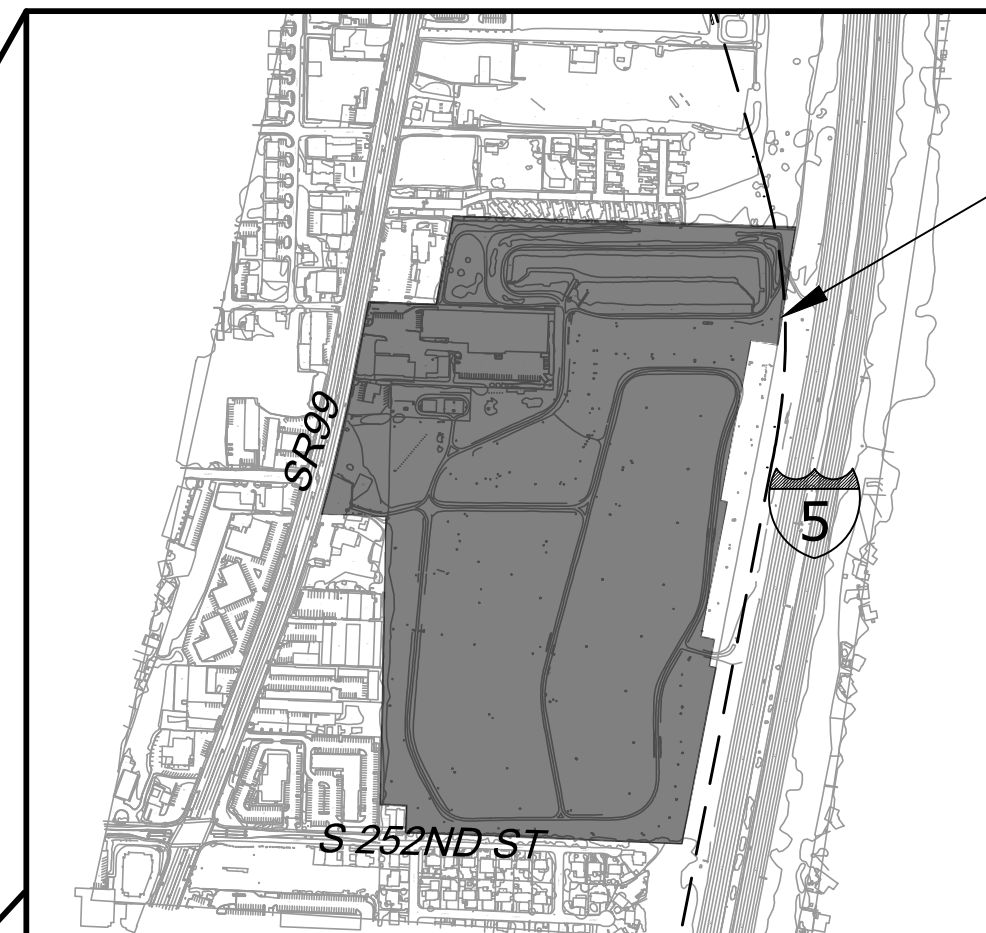


PROJECT LOCATION MIDWAY LANDFILL

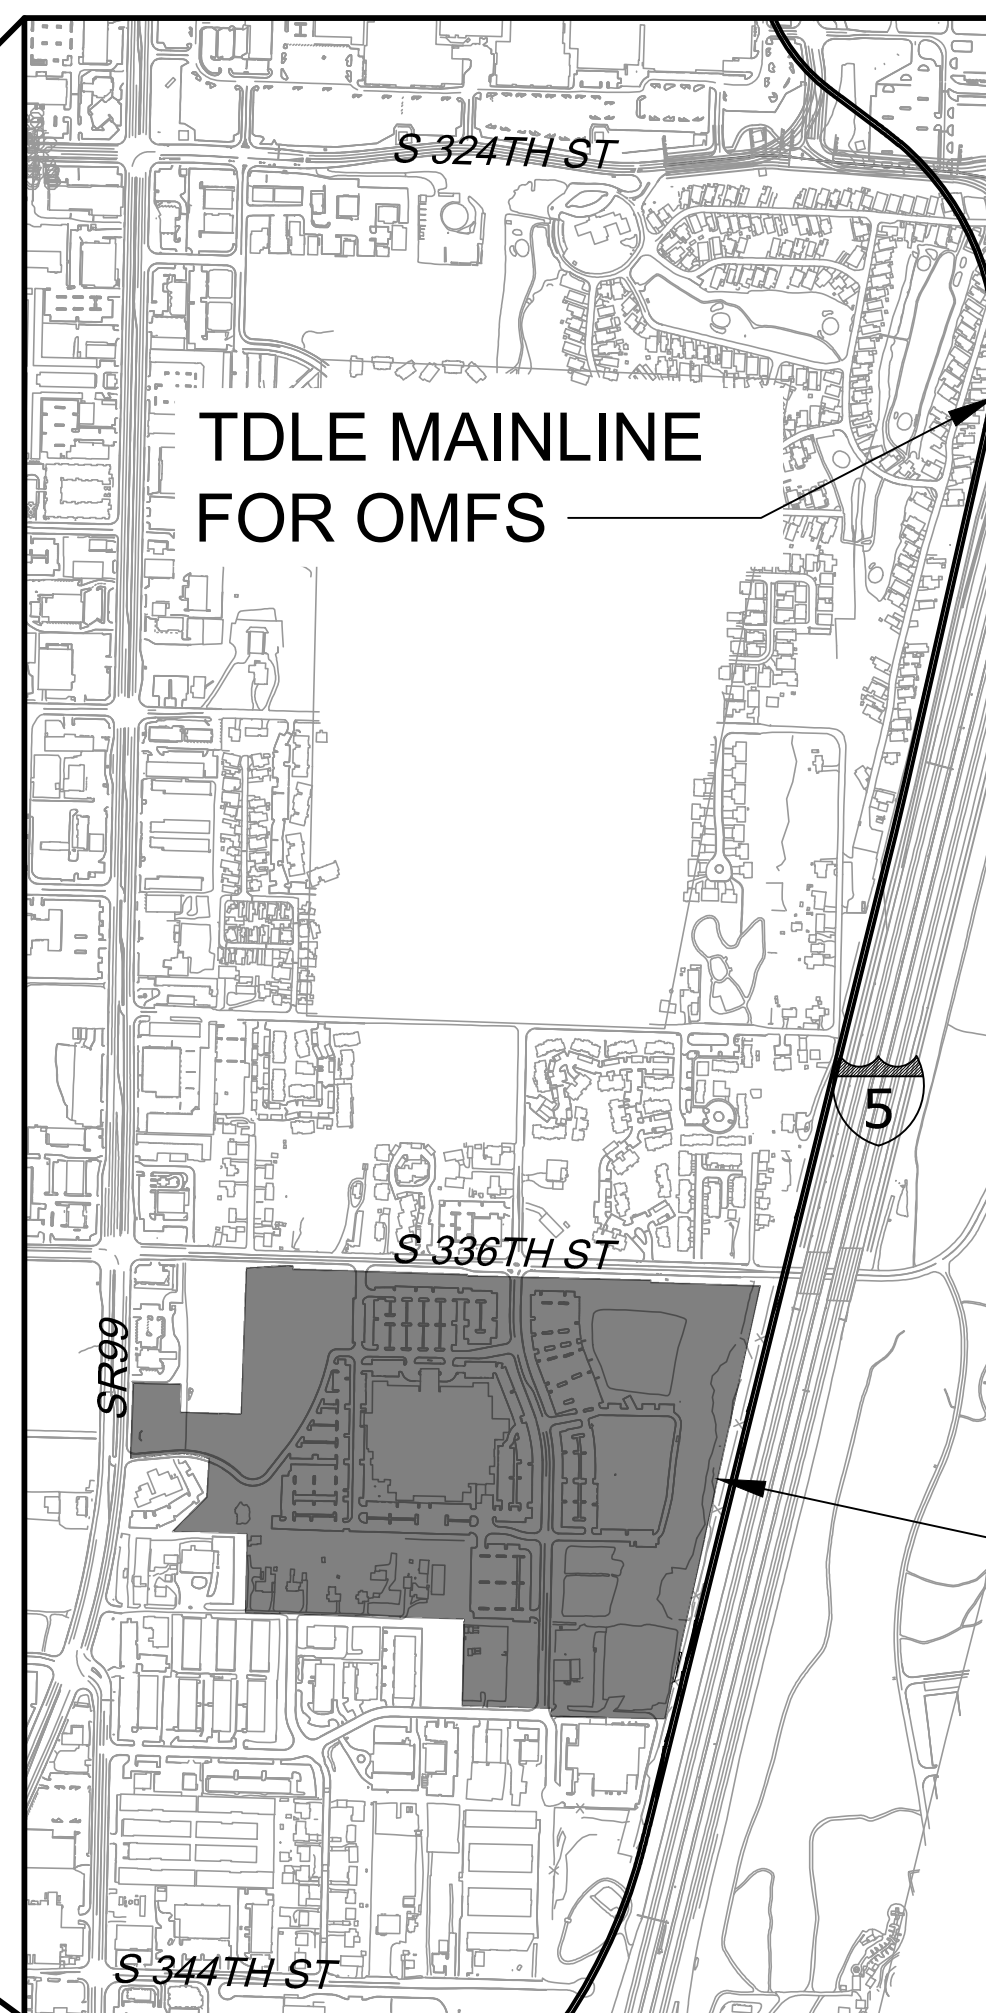

TDLE MAINLINE FOR OMFS —


PROJECT LOCATION
S 336TH ST

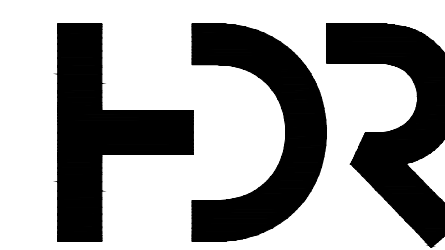

CIVIL ENGINEERING PRELIMINARY DESIGN CONSULTANT

Approved: _____ Date: _____

Project Manager

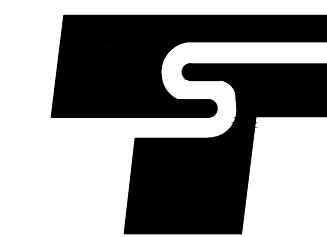

SOUNDTRANSIT

CENTRAL PUGET SOUND REGIONAL TRANSIT AUTHORITY

Approved: _____ Date: _____

Civil Engineering Manager

CONCEPTUAL
ENGINEERING

NOT FOR
CONSTRUCTION

DRAWING No.:

G01-GZI001

Scale:
NOT TO SCALE

SHEET No.: ii

PROJECT LOCATION MAPS

INDEX OF DRAWINGS


SHEET NO.	DWG. NO.	TITLE
GENERAL DRAWINGS		
i	COVER	COVER SHEET
ii	G01-GZI001	PROJECT LOCATION MAP
iii	G01-GZI005	INDEX OF DRAWINGS
MIDWAY LANDFILL		
1	M06A-ASP001	MIDWAY LANDFILL ARCHITECTURAL SITE PLAN
2	M06A-GSX101	MIDWAY LANDFILL - OPTION 1 GENERAL SITE SECTION
3	M06A-CGX101	MIDWAY LANDFILL - OPTION 1 GRADING CROSS SECTIONS
4	M06A-SFP101	MIDWAY LANDFILL - OPTION 1 STRUCTURAL PLATFORM PLAN
5	M06A-GSX201	MIDWAY LANDFILL - OPTION 2 GENERAL SITE SECTION
6	M06A-CGX201	MIDWAY LANDFILL - OPTION 2 GRADING CROSS SECTIONS
7	M06A-SFP201	MIDWAY LANDFILL - OPTION 2 STRUCTURAL SLAB PLAN
8	M06A-GSX301	MIDWAY LANDFILL - OPTION 3 GENERAL SITE SECTION
9	M06A-CGX301	MIDWAY LANDFILL - OPTION 3 GRADING CROSS SECTIONS
TDLE MAINLINE FOR OMFS		
10	S08A-KAP000	TDLE MAINLINE FOR OMFS TRACK TRACK KEY MAP
11	S08A-KAP100	TDLE MAINLINE FOR OMFS TRACK PLAN AND PROFILE S FEDERAL WAY ENCHANTED PKWY
12	S08A-KAP101	TDLE MAINLINE FOR OMFS TRACK PLAN AND PROFILE S FEDERAL WAY ENCHANTED PKWY
13	S08A-KAP102	TDLE MAINLINE FOR OMFS TRACK PLAN AND PROFILE S FEDERAL WAY ENCHANTED PKWY
14	S08A-KAP103	TDLE MAINLINE FOR OMFS TRACK PLAN AND PROFILE S FEDERAL WAY ENCHANTED PKWY
15	S08A-KAP104	TDLE MAINLINE FOR OMFS TRACK PLAN AND PROFILE S FEDERAL WAY ENCHANTED PKWY
16	S08A-KAP105	TDLE MAINLINE FOR OMFS TRACK PLAN AND PROFILE S FEDERAL WAY ENCHANTED PKWY
17	S08A-KAP106	TDLE MAINLINE FOR OMFS TRACK PLAN AND PROFILE S FEDERAL WAY ENCHANTED PKWY
18	S08A-KAP107	TDLE MAINLINE FOR OMFS TRACK PLAN AND PROFILE S FEDERAL WAY ENCHANTED PKWY
19	S08A-KAP108	TDLE MAINLINE FOR OMFS TRACK PLAN AND PROFILE S FEDERAL WAY ENCHANTED PKWY
20	S08A-KAP109	TDLE MAINLINE FOR OMFS TRACK PLAN AND PROFILE S FEDERAL WAY ENCHANTED PKWY
21	B00-KAP01	TDLE MAINLINE FOR OMFS TRACK PLAN AND PROFILE ALT B (55MPH DESIGN OPTION)
22	B00-KAP02	TDLE MAINLINE FOR OMFS TRACK PLAN AND PROFILE ALT B (55MPH DESIGN OPTION)
23	S08C-KAP201	TDLE MAINLINE FOR OMFS TRACK PLAN AND PROFILE I-5 OPTION
24	S08C-KAP202	TDLE MAINLINE FOR OMFS TRACK PLAN AND PROFILE I-5 OPTION
25	M06B-ASP601	S 336TH ST ARCHITECTURAL SITE PLAN
26	M06B-CGX601	S 336TH ST GRADING CROSS SECTIONS
27	M06B-CDP651	S 336TH ST CREEK DRAINAGE PLAN
28	M06C-ASP701	S 344TH ST ARCHITECTURAL SITE PLAN
29	M06C-CGX701	S 344TH ST GRADING CROSS SECTIONS
30	M06C-CDP751	S 344TH ST CREEK DRAINAGE PLAN

CONCEPTUAL ENGINEERING


NOT FOR
CONSTRUCTION

10% CONCEPTUAL ENGINEERING						DESIGNED BY: J. TYLER			LINE IS 1" AT FULL SCALE 	SCALE: NTS	SOUND TRANSIT OPERATIONS & MAINTENANCE FACILITY SOUTH CONCEPTUAL ENGINEERING INDEX OF DRAWINGS	DRAWING No.: G01-GZI005	
						DRAWN BY: J. TYLER				FILENAME: DEIS_OMFS-G01-GZI005-006		FACILITY ID:	
						CHECKED BY: T. MUDAYANKAVIL				CONTRACT No.:		SHEET No.:	REV:
						APPROVED BY:						iii	
No.	DATE	DSN	CHK	APP	REVISION	T. MUDAYANKAVIL							
						SUBMITTED BY: THOMAS MUDAYANKAVIL	DATE: JULY 1, 2020	REVIEWED BY:	DATE: JULY 1, 2020				

01/19/21 | 8:27 AM | PLOPEZHILF
C:\PWORKING\WEST01\101861911\OMFS-M06A-ASP001.DWG

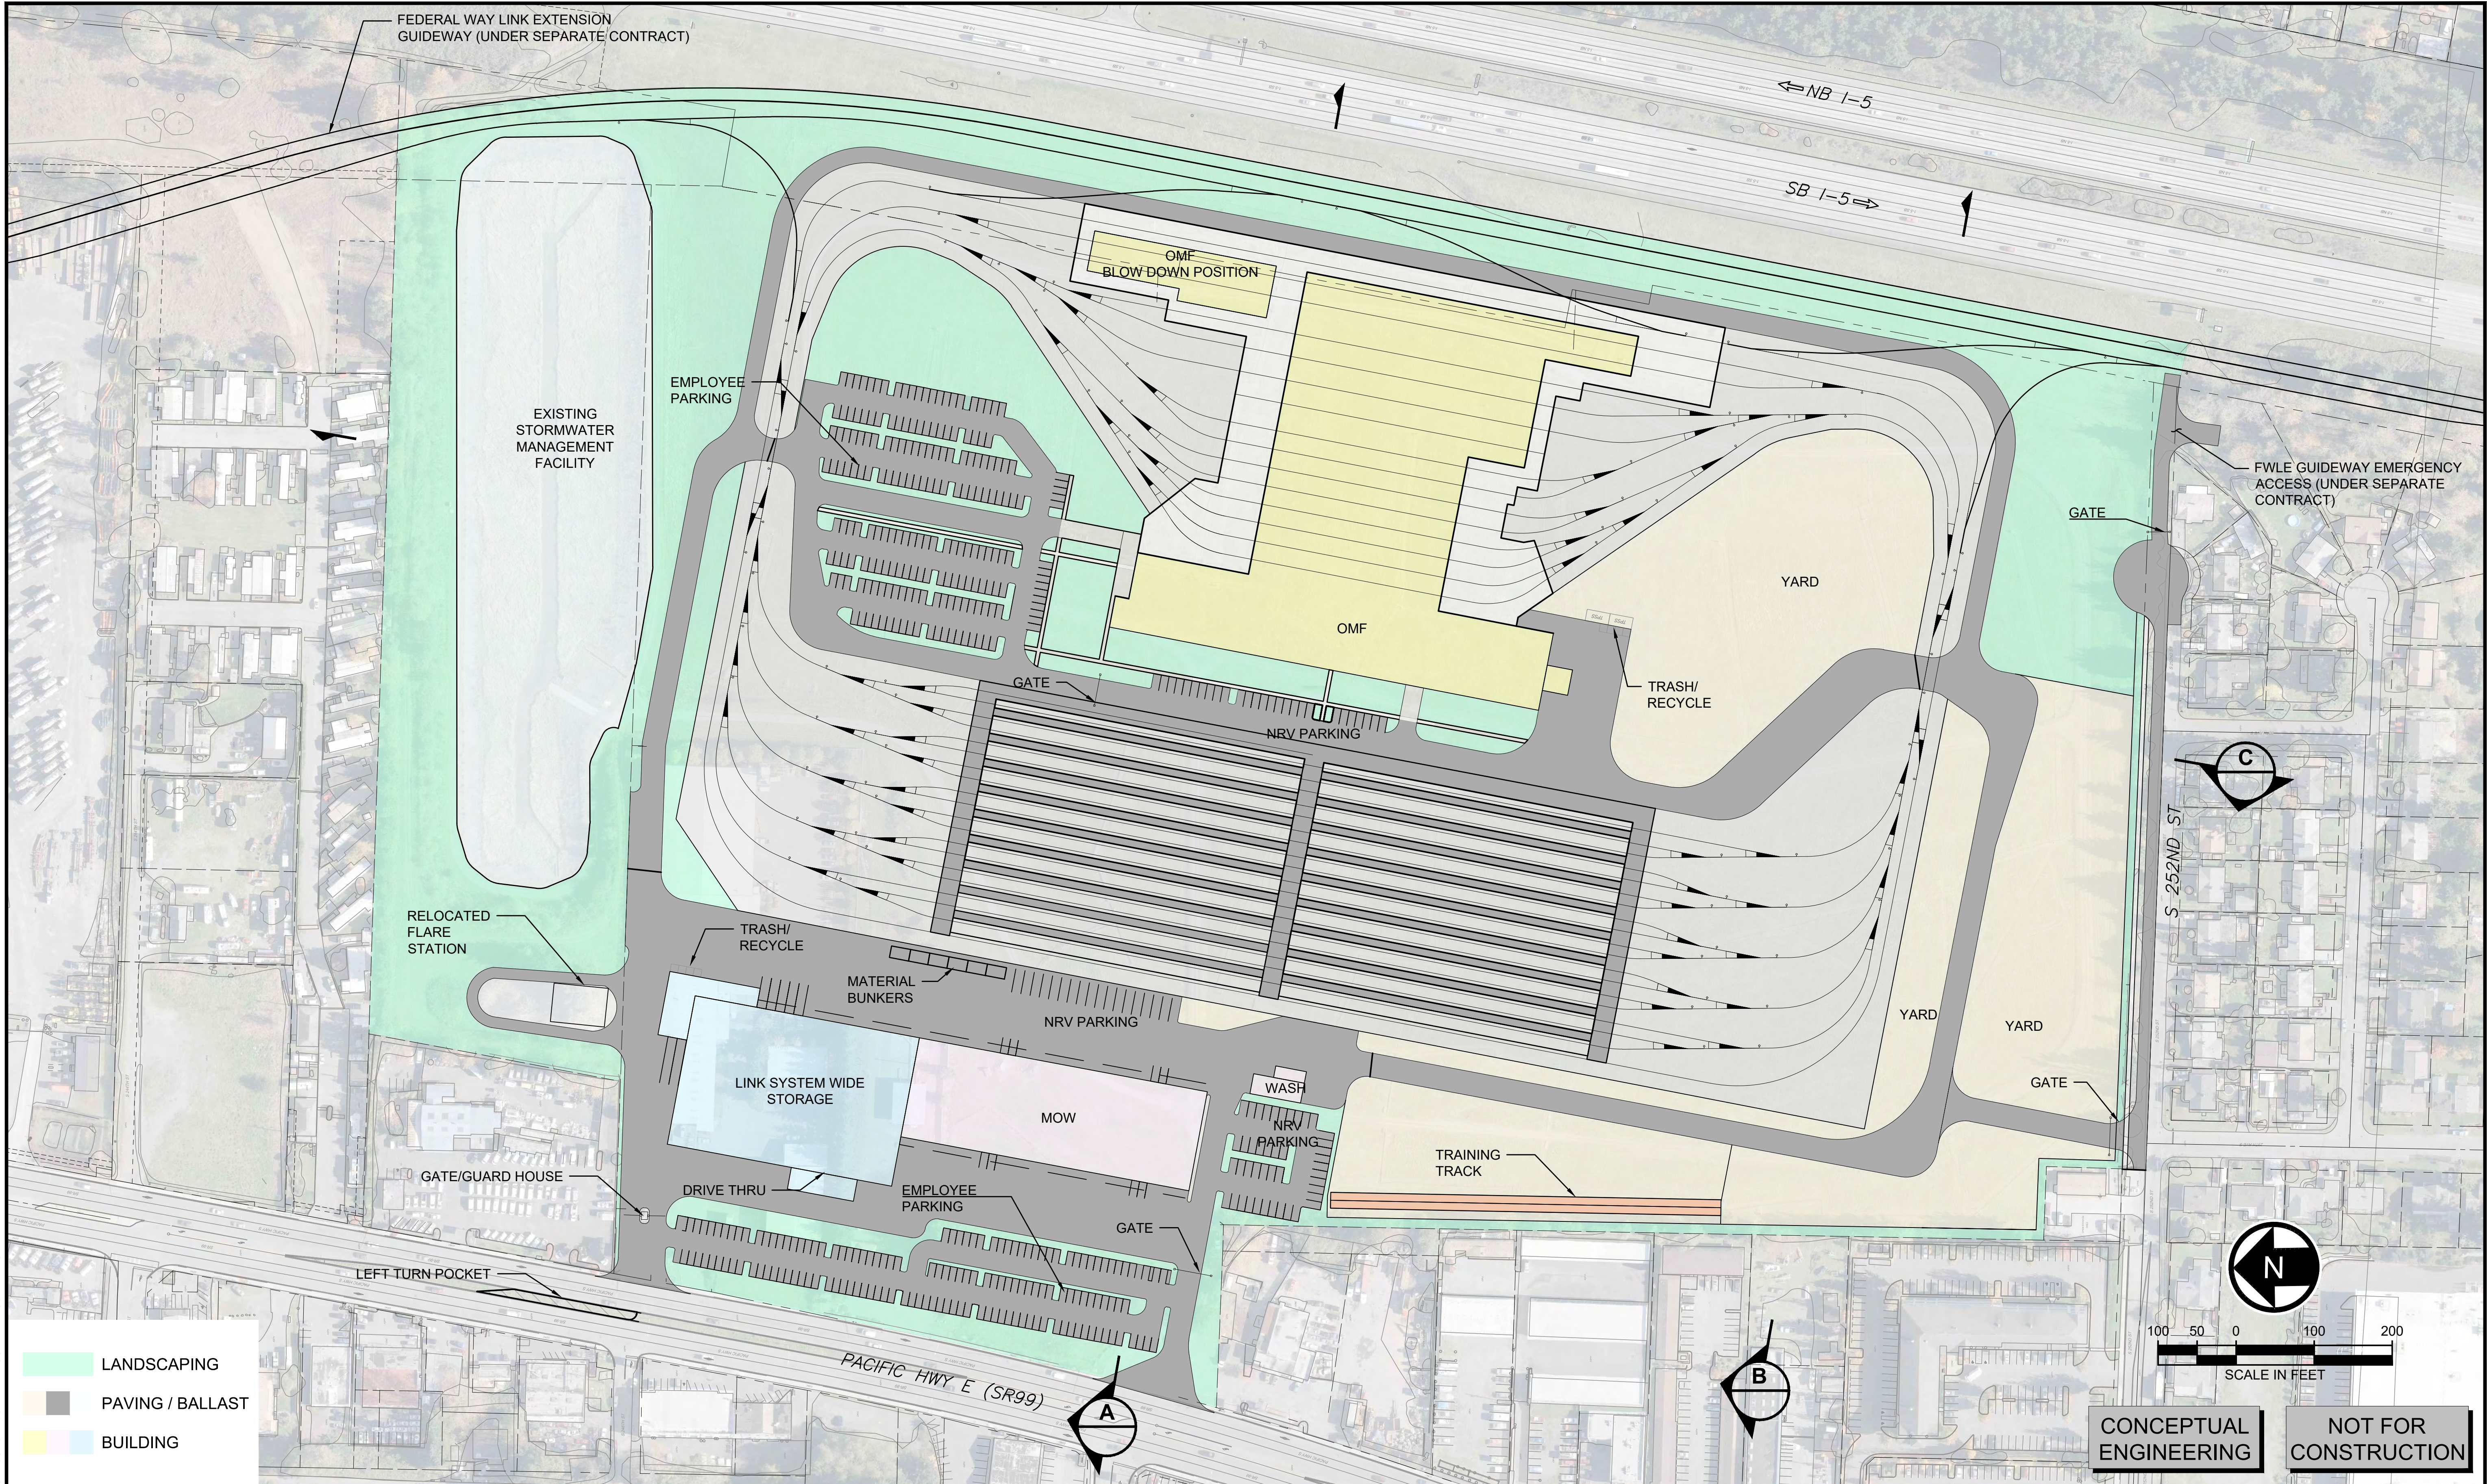

10% CONCEPTUAL ENGINEERING					
No.	DATE	DSN	CHK	APP	REVISION

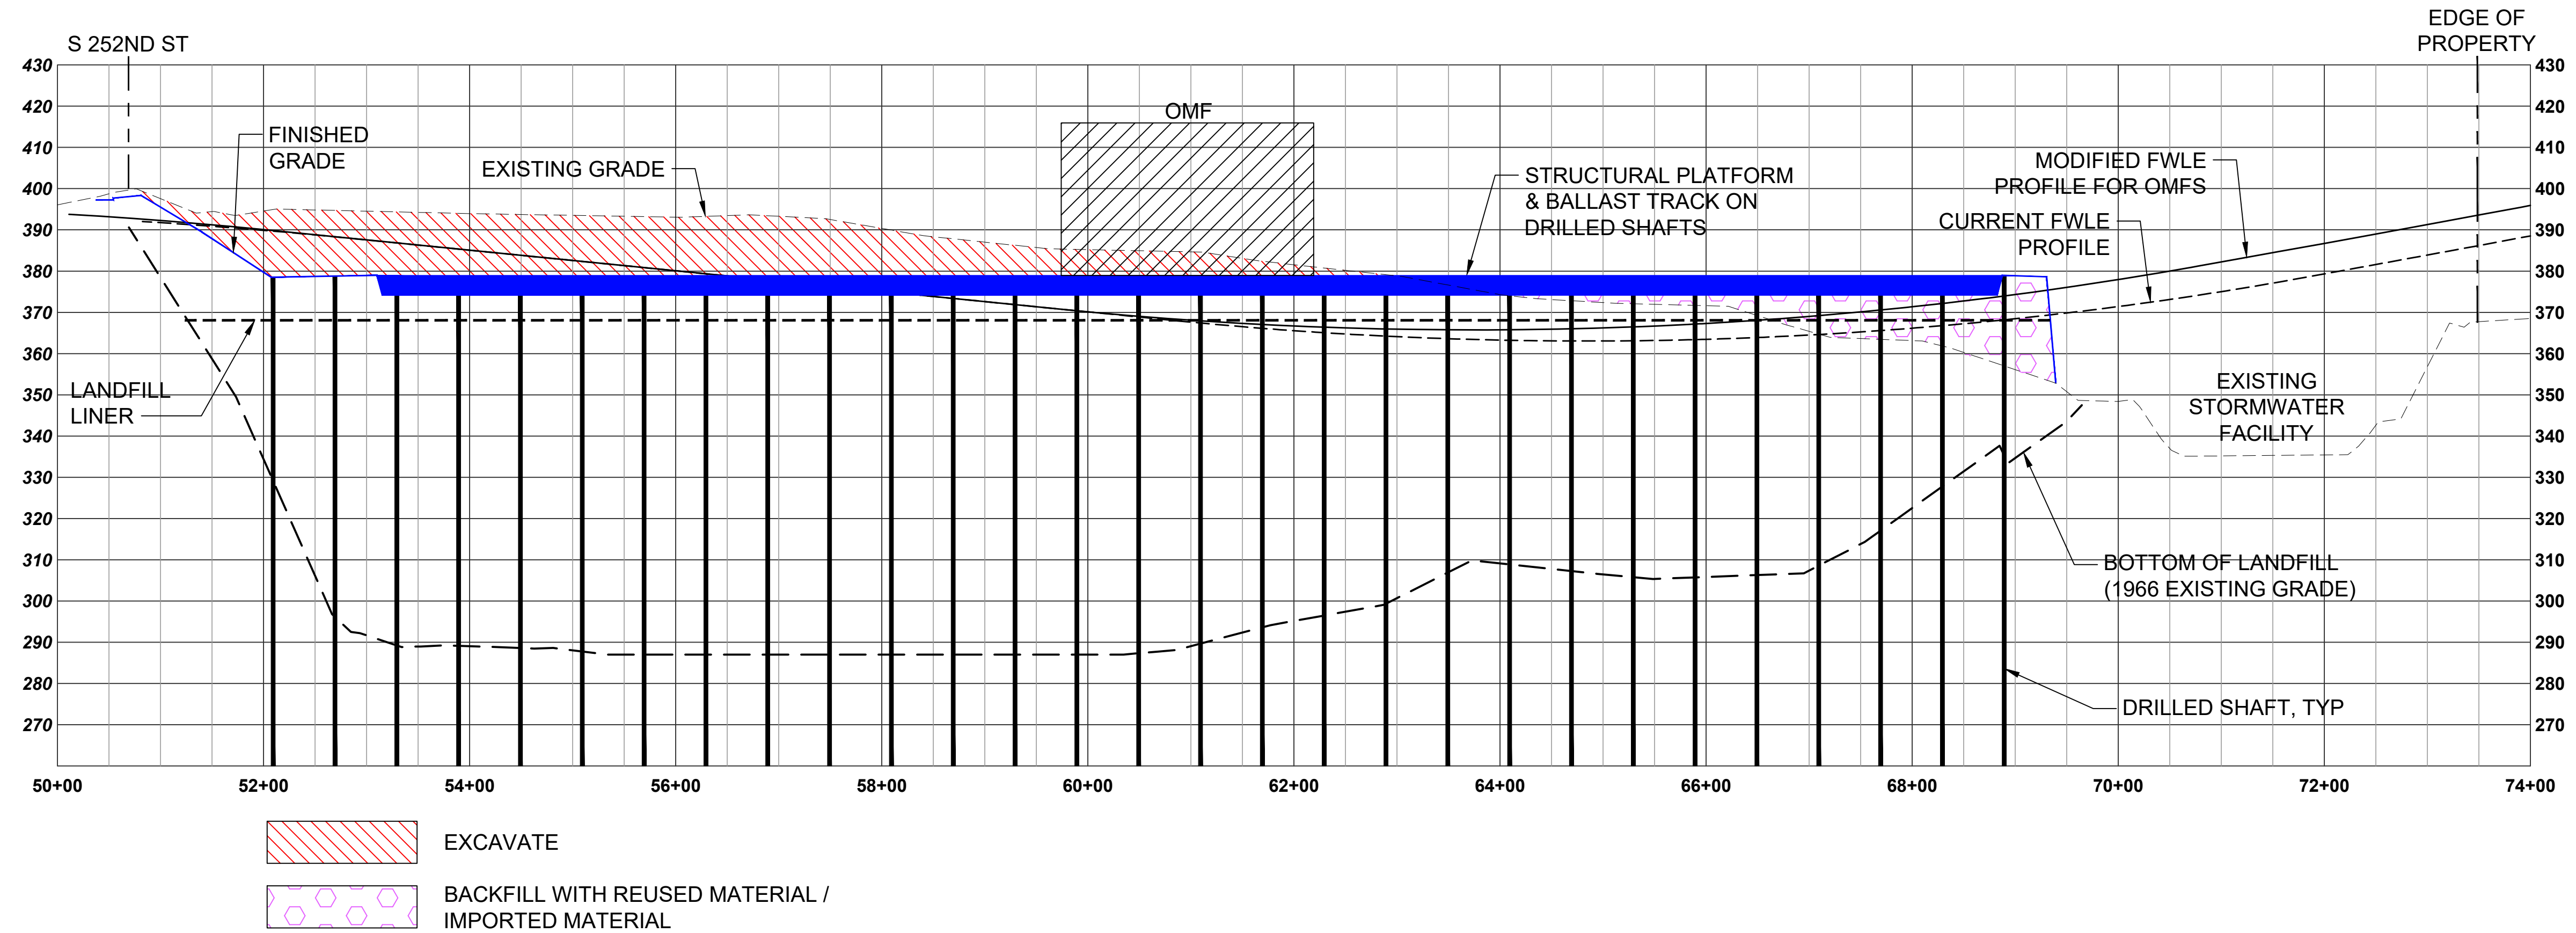

MIDWAY LANDFILL - OPTION 1 , LOW STRUCTURAL PLATFORM


SCALE: 1" = 100'

CONCEPTUAL
ENGINEERING

NOT FOR
CONSTRUCTION

10% CONCEPTUAL ENGINEERING

DESIGNED BY:
P. LOPEZ-HILFIKER
DRAWN BY:
P. LOPEZ-HILFIKER
CHECKED BY:
J. HARPER
APPROVED BY:
P. LOPEZ-HILFIKER

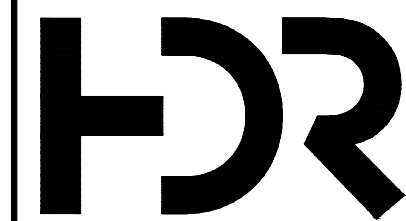

SUBMITTED BY:
THOMAS MUDAYANKAVIL

DATE:
March 1, 2021

REVIEWED BY:

LINE IS 1" AT
FULL SCALE




SCALE:
1"=100'
FILENAME:
DEIS_OMFS-M06A-GSX001
CONTRACT No.:
DATE:


SOUND TRANSIT
OPERATIONS & MAINTENANCE FACILITY SOUTH
CONCEPTUAL ENGINEERING
MIDWAY LANDFILL - OPTION 1
GENERAL SITE SECTION

DRAWING No.:
M06A-GSX101
FACILITY ID:
SHEET No.:
REV:
2


01/19/21 | 9:08 AM | PLOPEZHILF
C:\PWORKING\WEST01\1861911\OMFS-M06A-CGX101.DWG

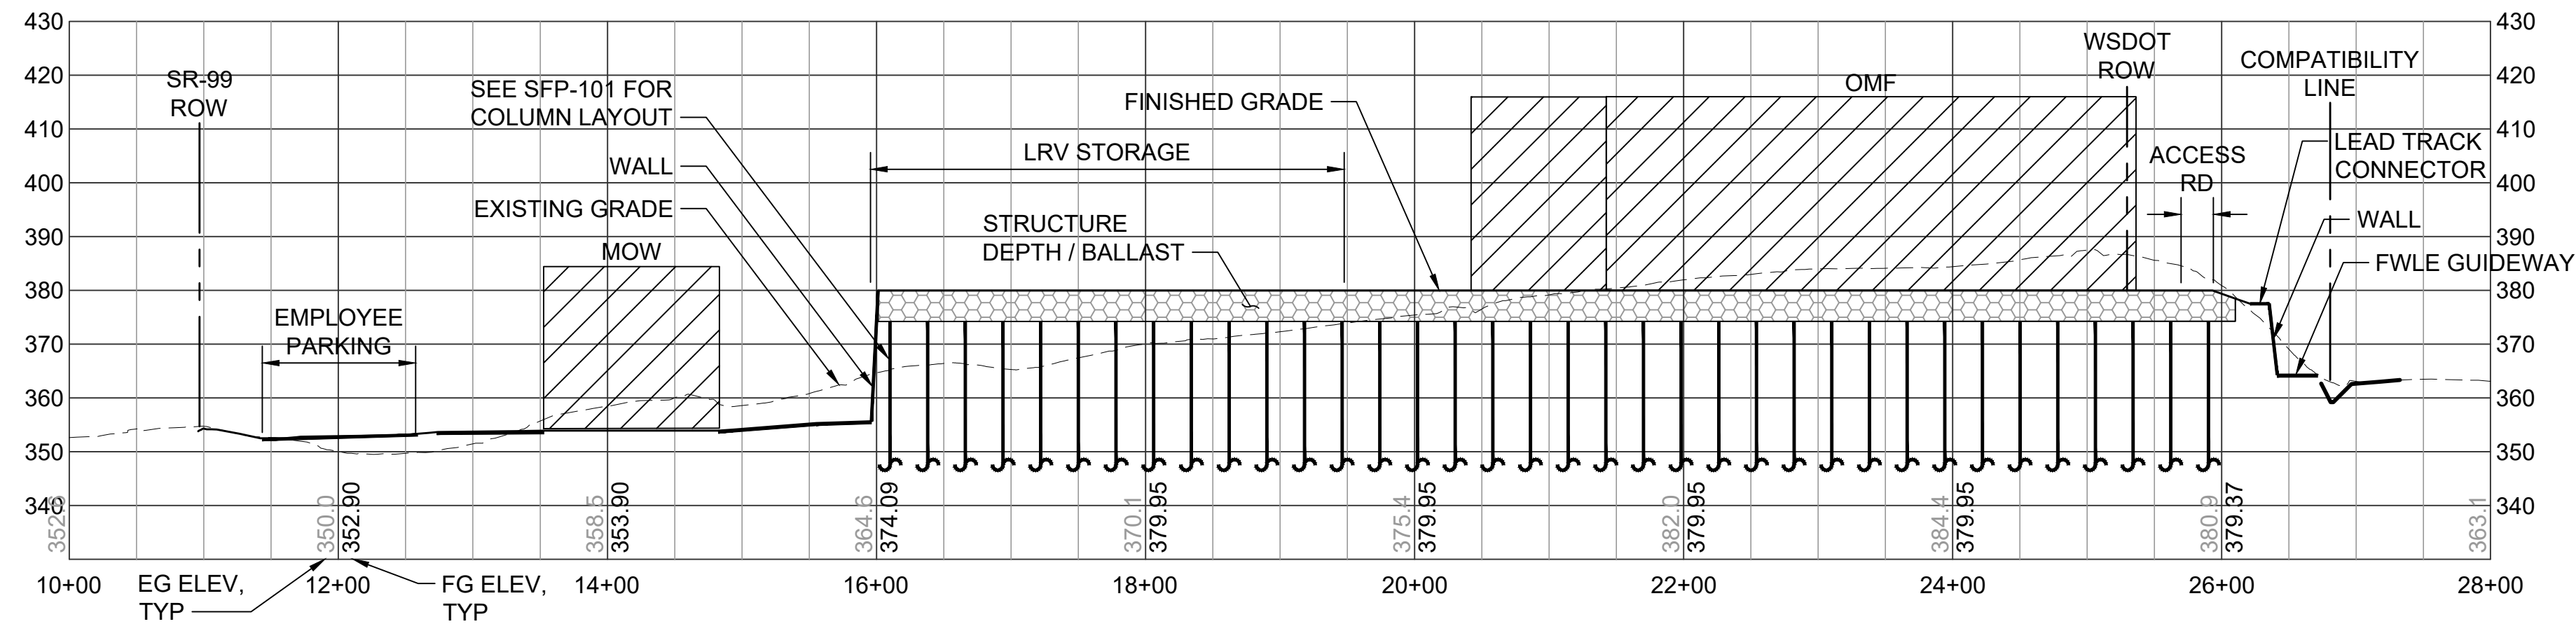


SECTION A
M06A-ASP001

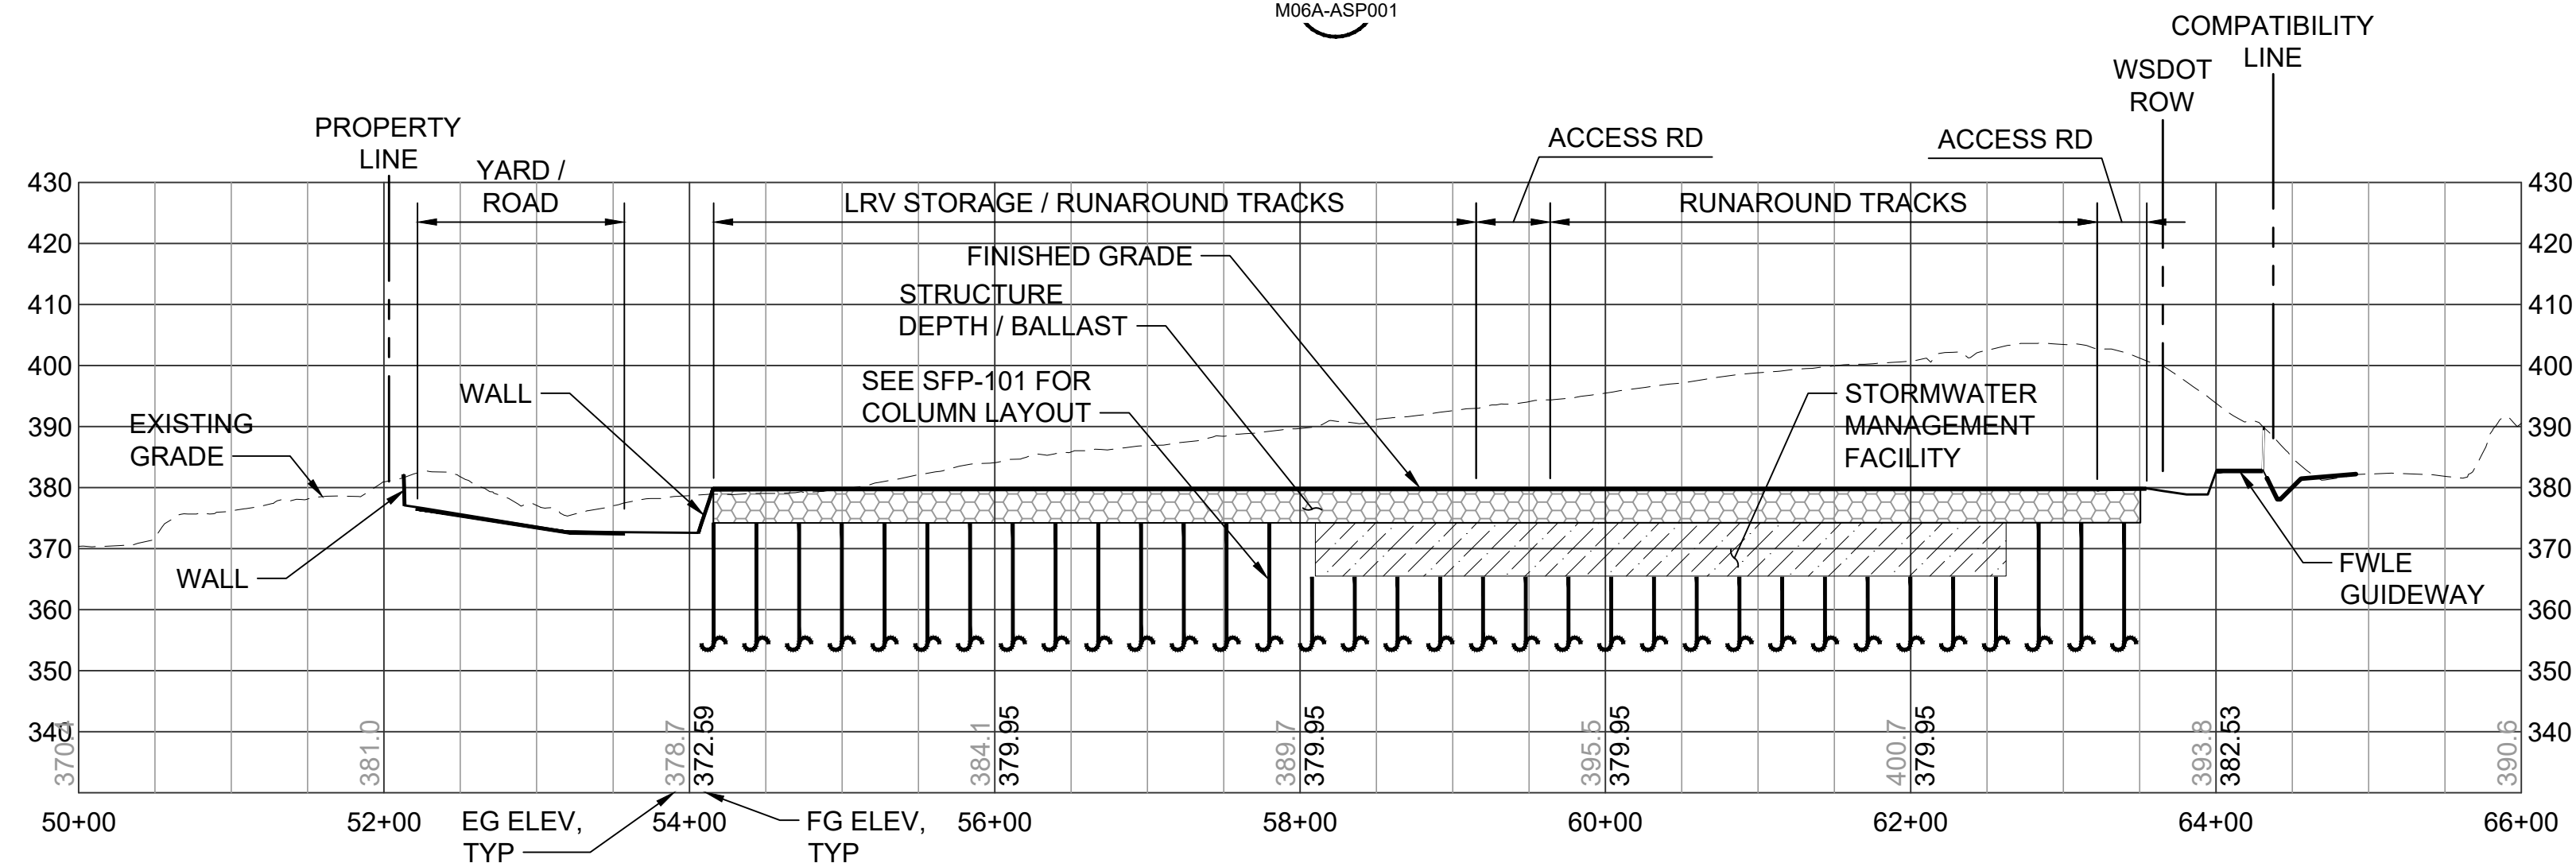

SECTION B
M06A-ASP001

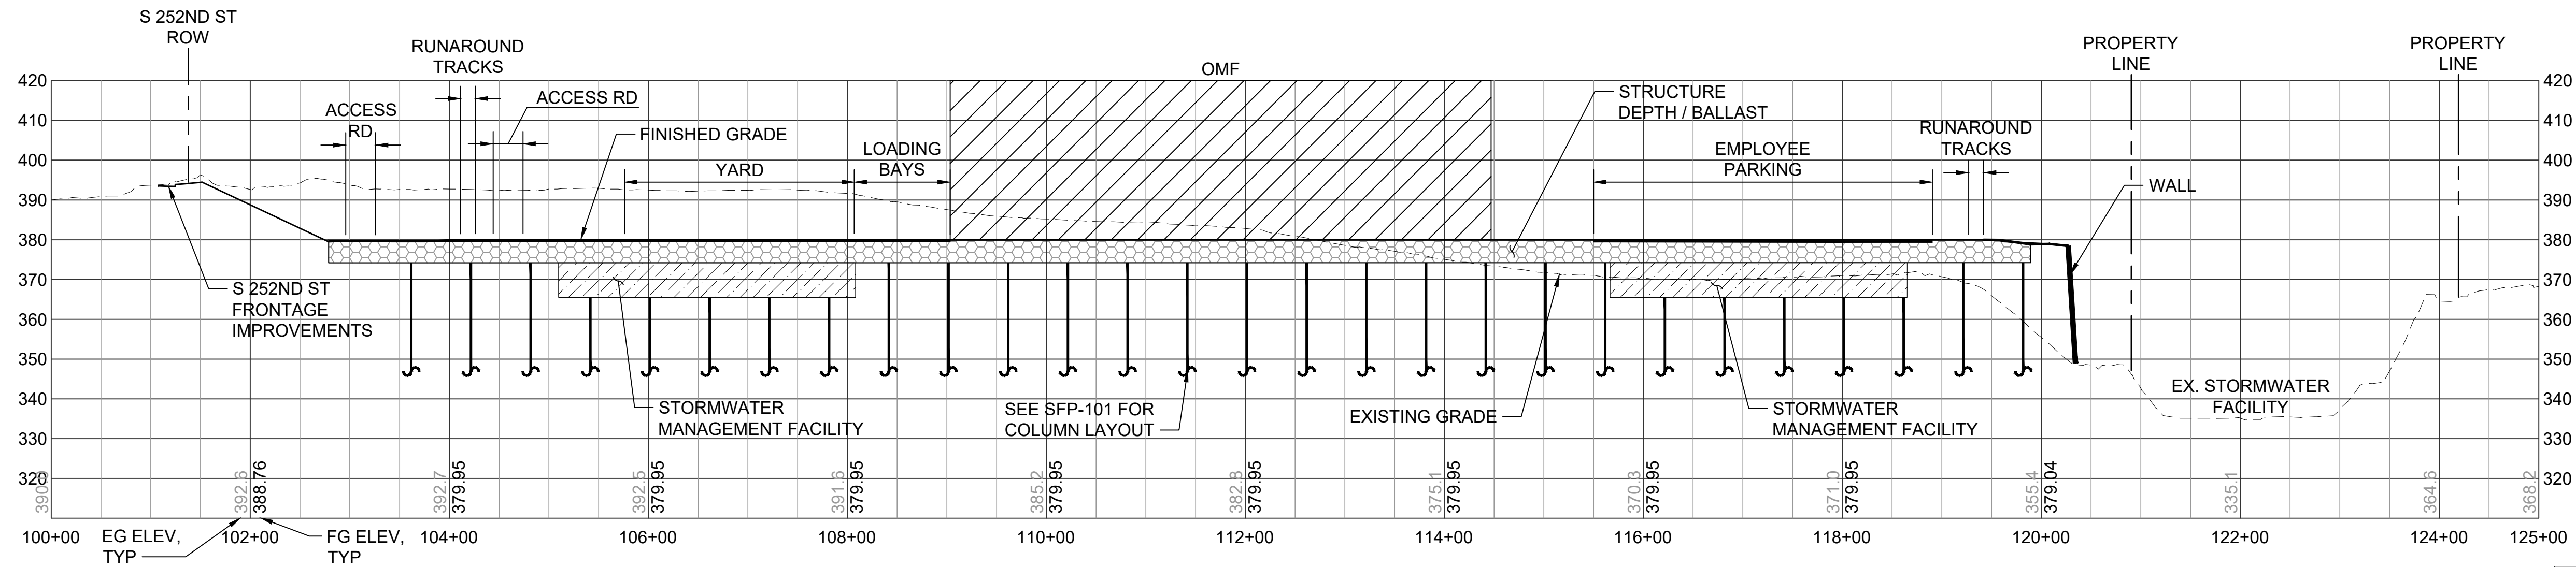

SECTION C
M06A-ASP001

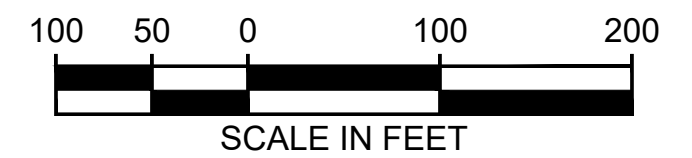


CONCEPTUAL
ENGINEERING

NOT FOR
CONSTRUCTION

10% CONCEPTUAL ENGINEERING

No.	DATE	DSN	CHK	APP	REVISION

DESIGNED BY:
P. LOPEZ-HILFIKER
DRAWN BY:
P. LOPEZ-HILFIKER
CHECKED BY:
J. HARPER
APPROVED BY:
P. LOPEZ-HILFIKER

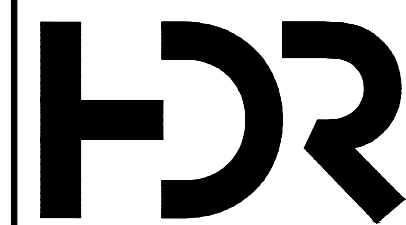

SUBMITTED BY:
THOMAS MUDAYANKAVIL

DATE:
MARCH 1, 2021

REVIEWED BY:

LINE IS "AT"
FULL SCALE



SCALE:
1"=100'
FILENAME:
OMFS-M06A-CGX101
CONTRACT No.:

DATE:
MARCH 1, 2021


SOUND TRANSIT
OPERATIONS & MAINTENANCE FACILITY SOUTH
CONCEPTUAL ENGINEERING
MIDWAY LANDFILL - OPTION 1
GRADING CROSS SECTIONS

DRAWING No.:
M06A-CGX101
FACILITY ID:
SHEET No.:
REV:
3

01/20/21 | 12:27 PM | PLOPEZHILF
C:\PWORKING\WEST01\1861911\OMFS-M06A-SFP101.DWG



DRILLED SHAFT

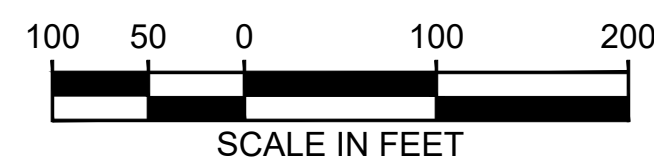

CONCEPTUAL
ENGINEERING

NOT FOR
CONSTRUCTION

10% CONCEPTUAL ENGINEERING

No.	DATE	DSN	CHK	APP	REVISION

DESIGNED BY:
Y. YANG
DRAWN BY:
J. TYLER
CHECKED BY:
J. MERTH
APPROVED BY:
Y. YANG



HR

SUBMITTED BY:
THOMAS MUDAYANKAVIL

Parametrix
ENGINEERING · PLANNING · ENVIRONMENTAL SCIENCES

DATE:
MARCH 1, 2021

LINE IS "AT"
FULL SCALE


SOUNDTRANSIT

DATE:
MARCH 1, 2021

SCALE:
1"=100'
FILENAME:
OMFS-M06A-SFP101
CONTRACT No.:
DATE:

SOUND TRANSIT
OPERATIONS & MAINTENANCE FACILITY SOUTH
CONCEPTUAL ENGINEERING
MIDWAY LANDFILL - OPTION 1
STRUCTURAL PLATFORM PLAN

DRAWING No.:
M06A-SFP101
FACILITY ID:
SHEET No.:
REV:
4

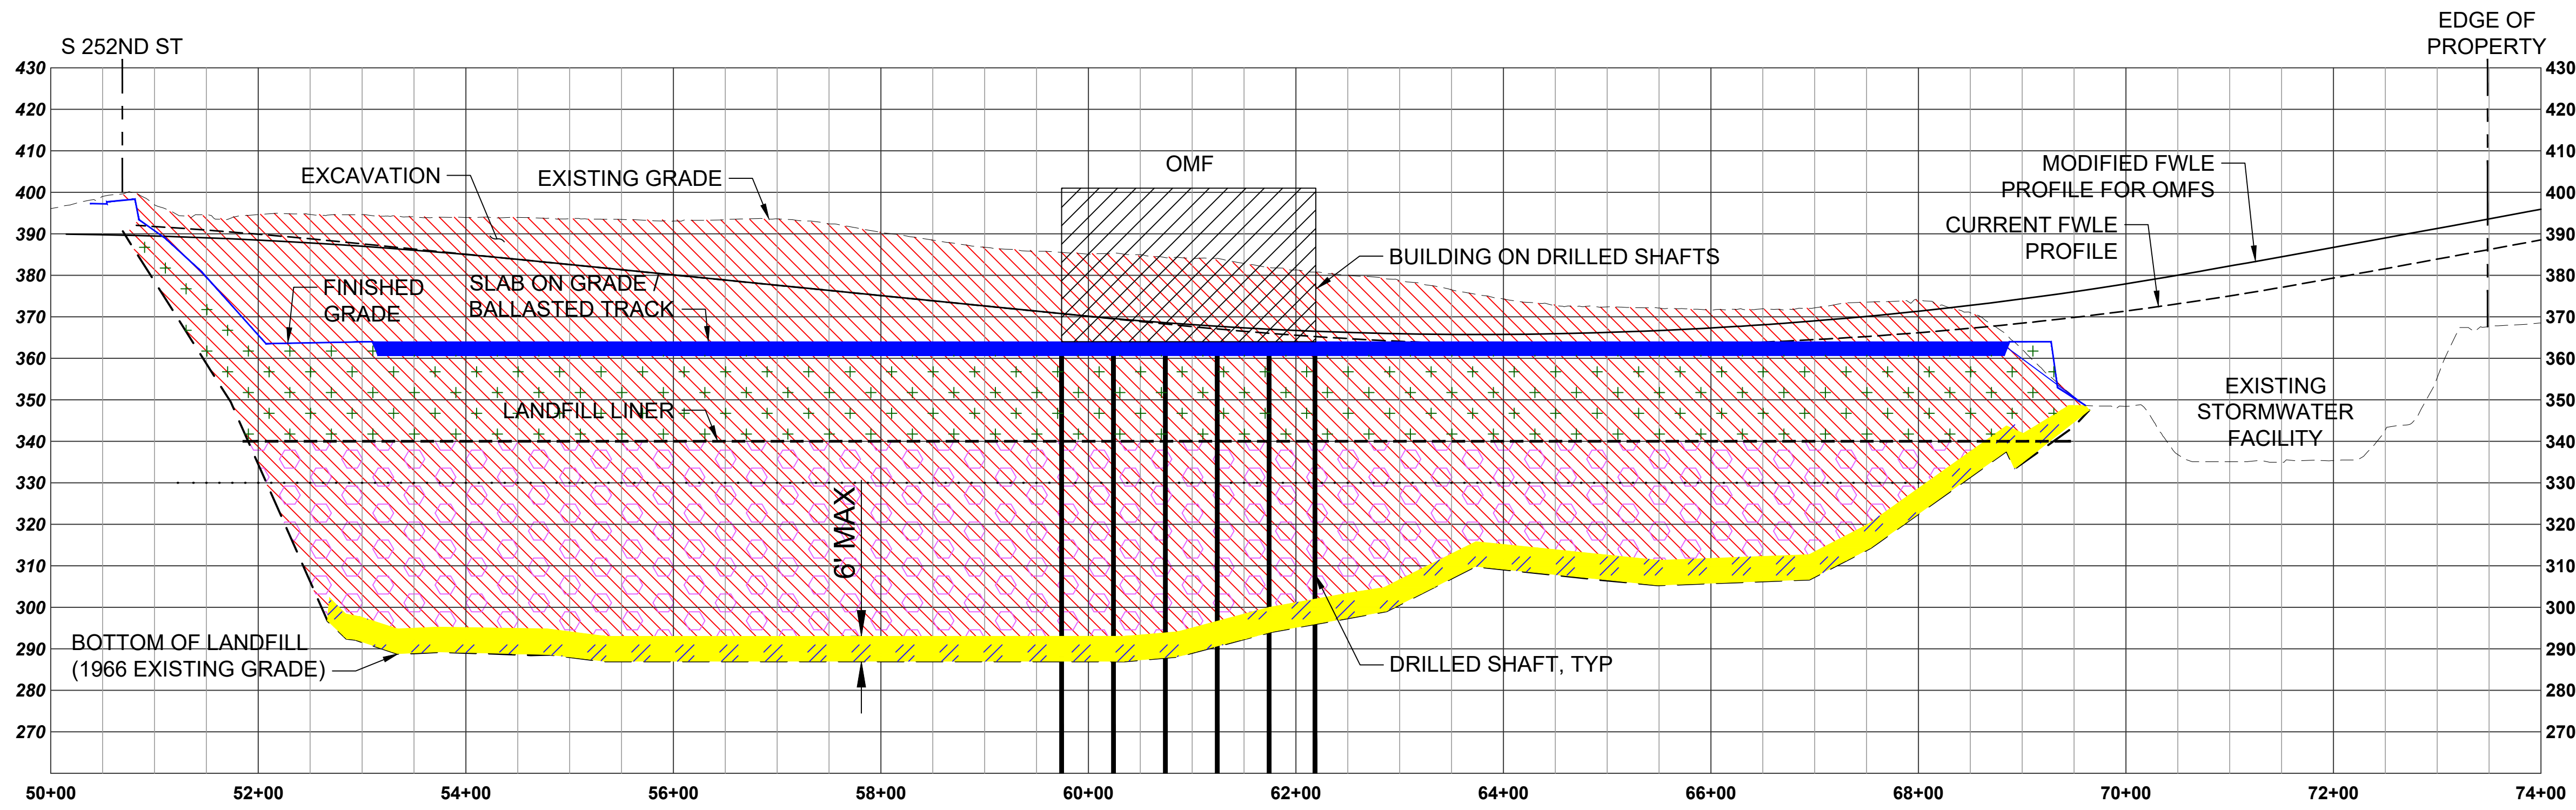

- EXCAVATE
- EXCAVATE & BACKFILL WITH IMPORTED MATERIAL
- EXCAVATE & BACKFILL WITH REUSE MATERIAL
- DEEP DYNAMIC COMPACTION


MIDWAY LANDFILL - OPTION 2, HYBRID PLATFORM
SCALE: 1" = 100'

CONCEPTUAL ENGINEERING NOT FOR CONSTRUCTION

10% CONCEPTUAL ENGINEERING

No.	DATE	DSN	CHK	APP	REVISION

DESIGNED BY:
P. LOPEZ-HILFIKER
DRAWN BY:
P. LOPEZ-HILFIKER
CHECKED BY:
J. HARPER
APPROVED BY:
P. LOPEZ-HILFIKER

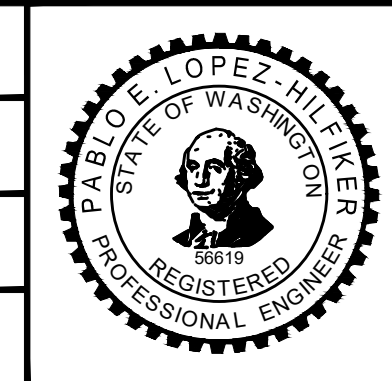

SUBMITTED BY:
THOMAS MUDAYANKAVIL

DATE:
March 1, 2021

REVIEWED BY:

DATE:
March 1, 2021


LINE IS 1" AT FULL SCALE

SCALE:
1"=100'
FILENAME:
DEIS_OMFS-M06A-GSX001
CONTRACT No.:



SOUND TRANSIT
OPERATIONS & MAINTENANCE FACILITY SOUTH
CONCEPTUAL ENGINEERING
MIDWAY LANDFILL - OPTION 2
GENERAL SITE SECTION

DRAWING No.:
M06A-GSX201
FACILITY ID:
SHEET No.:
5
REV:


01/19/21 | 9:16 AM | PLOPEZHILF
C:\PWORKING\WEST01\1861911\OMFS-M06A-CGX201.DWG

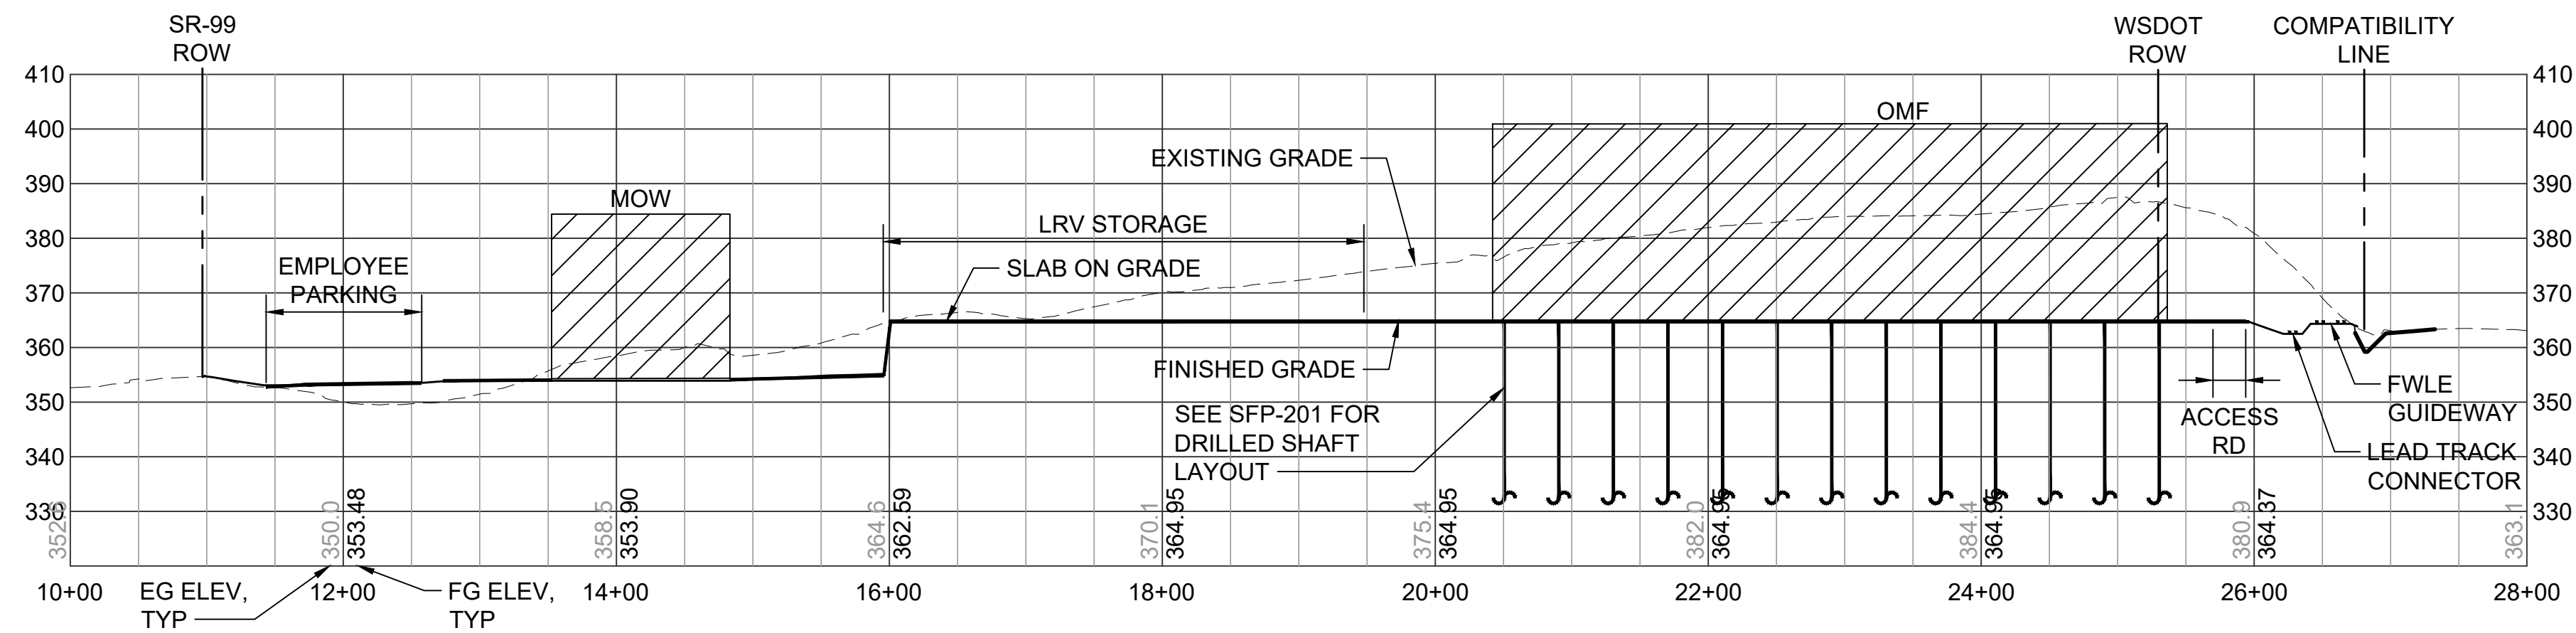

SECTION A
M06A-ASP001

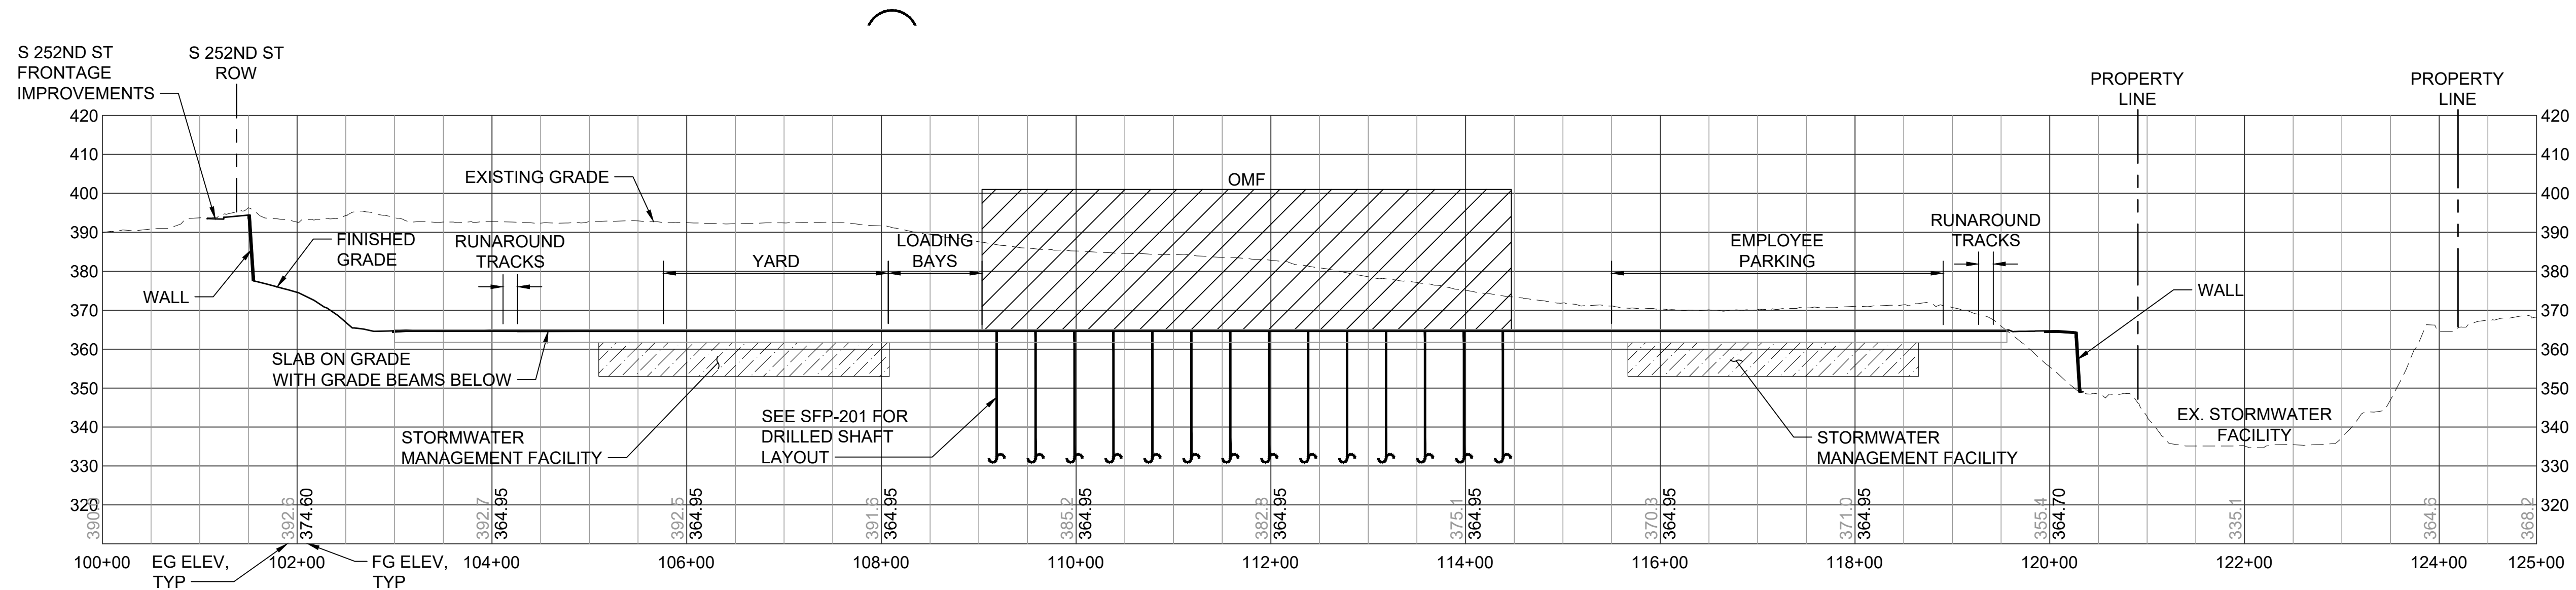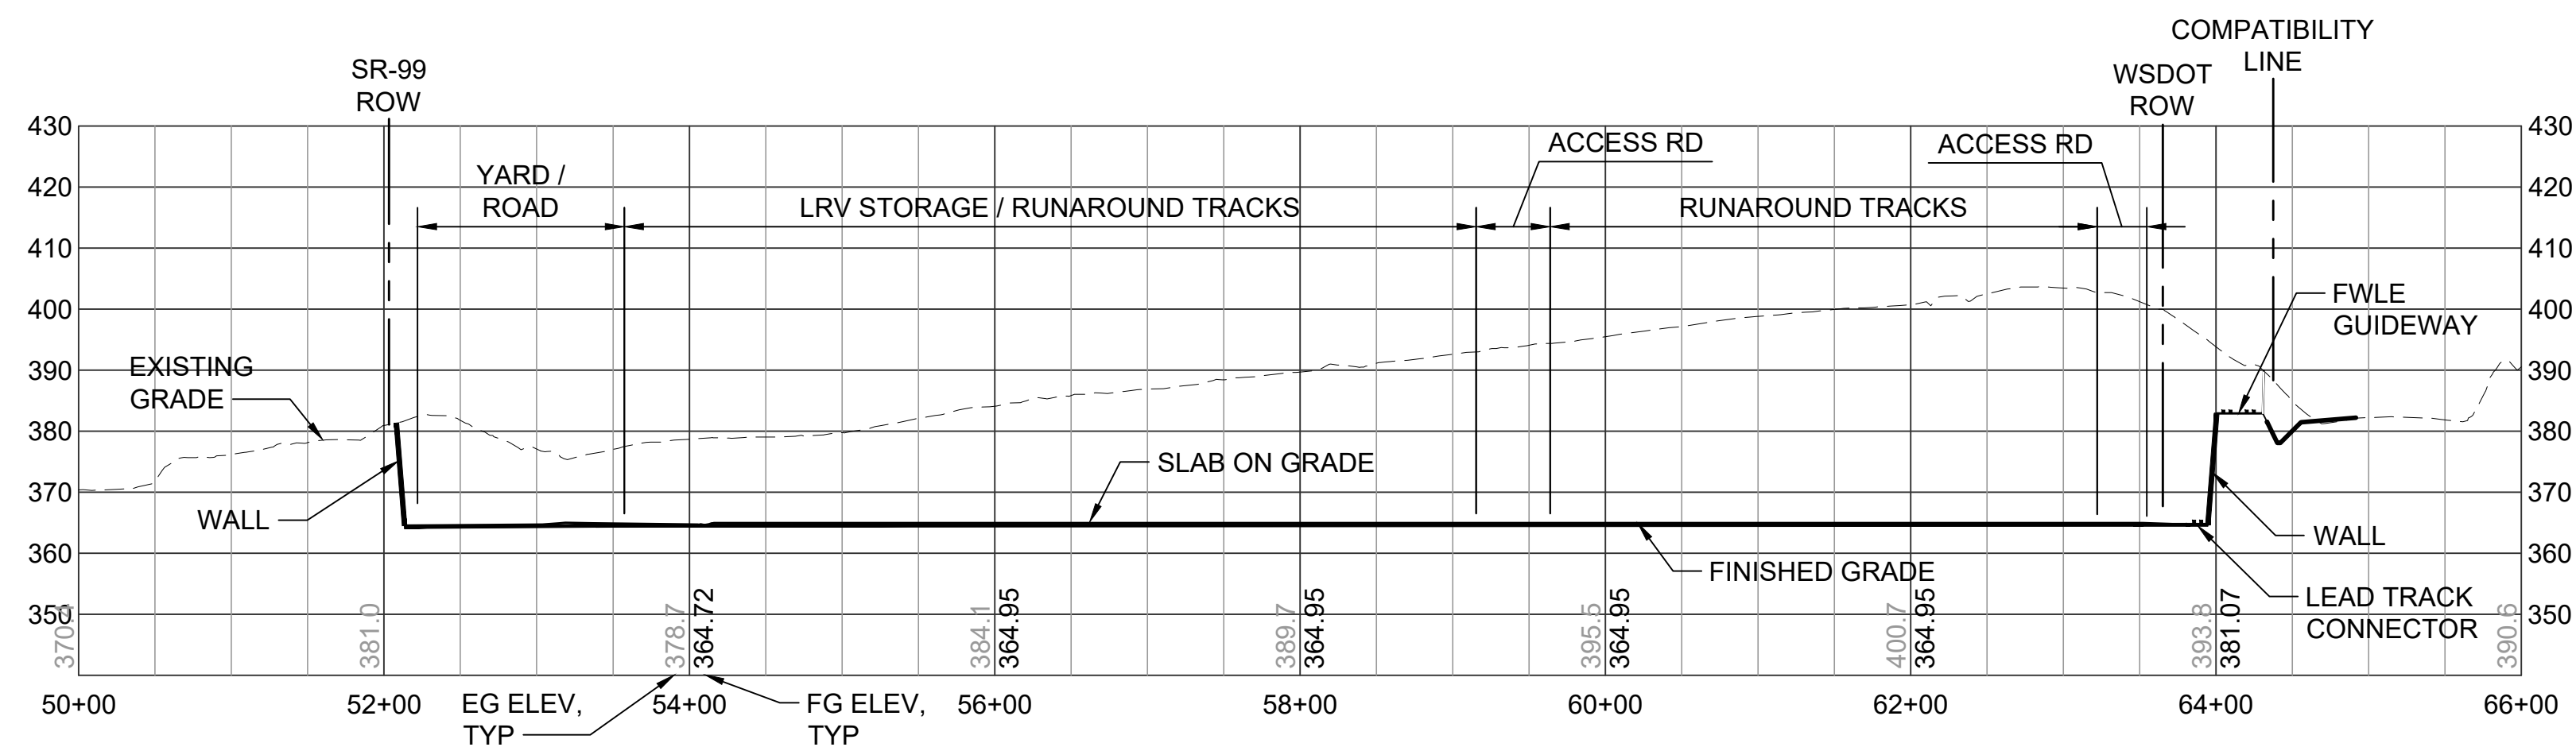

SECTION C
M06A-ASP001

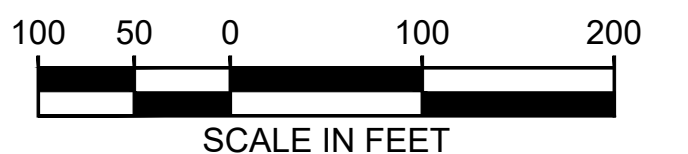


CONCEPTUAL
ENGINEERING

NOT FOR
CONSTRUCTION

10% CONCEPTUAL ENGINEERING

DESIGNED BY:
P. LOPEZ-HILFIKER
DRAWN BY:
P. LOPEZ-HILFIKER
CHECKED BY:
J. HARPER
APPROVED BY:
T. MUDAYANKAVIL

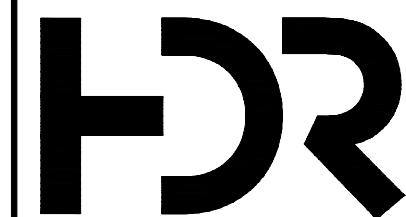

SUBMITTED BY:
THOMAS MUDAYANKAVIL

DATE:
MARCH 1, 2021

REVIEWED BY:

LINE IS "AT"
FULL SCALE



SCALE:
1"=100'
FILENAME:
OMFS-M06A-CGX201
CONTRACT No.:
DATE:


SOUND TRANSIT
OPERATIONS & MAINTENANCE FACILITY SOUTH
CONCEPTUAL ENGINEERING
MIDWAY LANDFILL - OPTION 2
GRADING CROSS SECTIONS

DRAWING No.:
M06A-CGX201
FACILITY ID:
SHEET No.:
REV:
6

01/19/21 | 9:36 AM | PLOPEZHILF
C:\PWORKING\WEST01\1811\OMFS-M06A-SFP201.DWG



□ DRILLED SHAFT

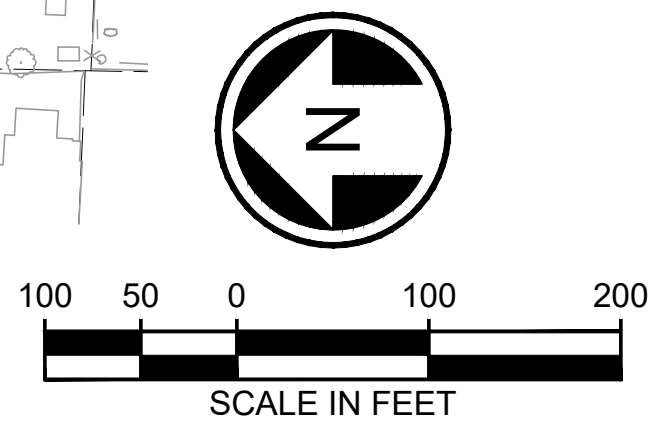

CONCEPTUAL
ENGINEERING

NOT FOR
CONSTRUCTION

10% CONCEPTUAL ENGINEERING


No.	DATE	DSN	CHK	APP	REVISION

DESIGNED BY:
Y. YANG

DRAWN BY:
J. TYLER

CHECKED BY:
J. MERTH

APPROVED BY:
Y. YANG

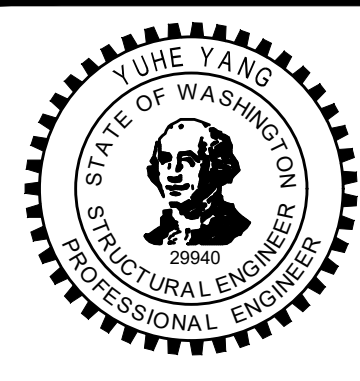

HR

SUBMITTED BY:
THOMAS MUDAYANKAVIL

Parametrix
ENGINEERING · PLANNING · ENVIRONMENTAL SCIENCES

DATE:
MARCH 1, 2021

REVIEWED BY:

DATE:
MARCH 1, 2021

SOUNDTRANSIT

DATE:
MARCH 1, 2021

SCALE:
1"=100'

FILENAME:
OMFS-M06A-SFP201

CONTRACT No.:

DATE:


SOUND TRANSIT
OPERATIONS & MAINTENANCE FACILITY SOUTH
CONCEPTUAL ENGINEERING
MIDWAY LANDFILL - OPTION 2
STRUCTURAL SLAB PLAN



DRAWING No.:
M06A-SFP201

FACILITY ID:

SHEET No.:
7

  REV:

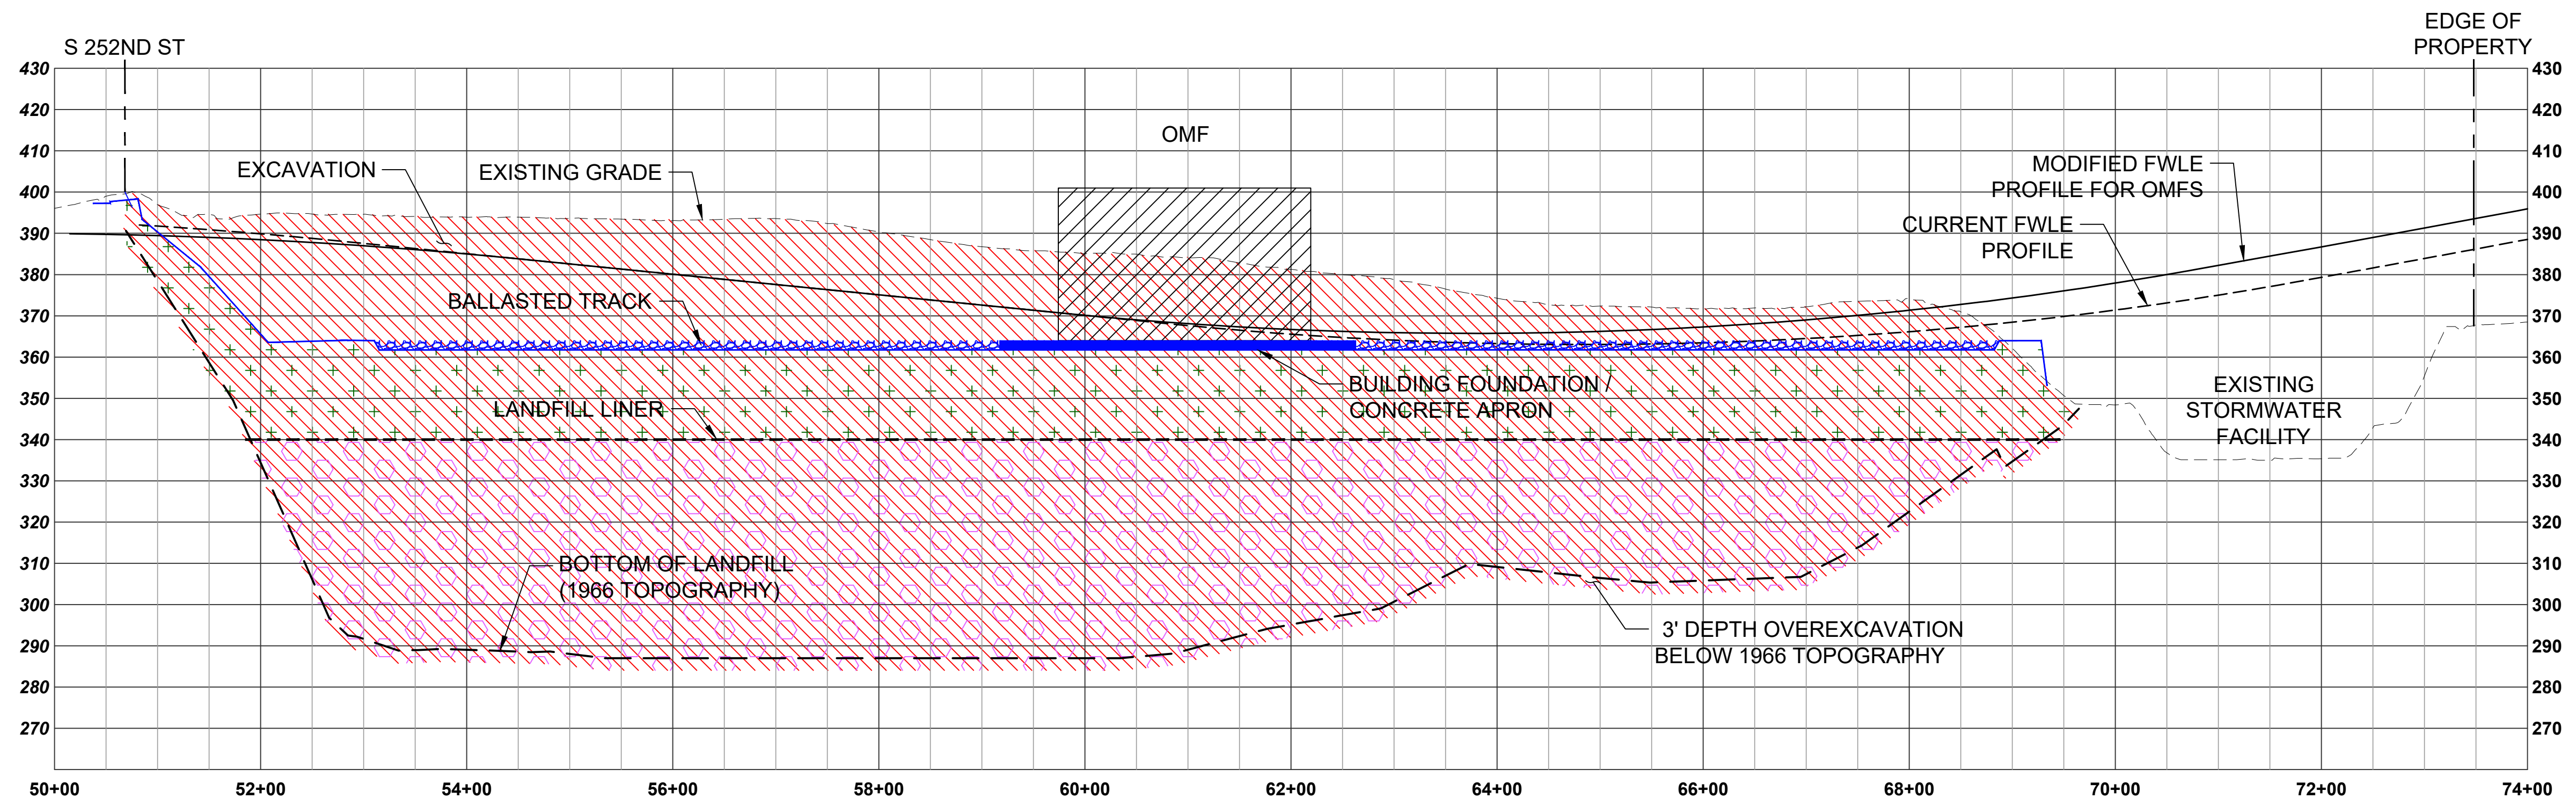


-  EXCAVATE
-  EXCAVATE & BACKFILL WITH IMPORTED MATERIAL
-  EXCAVATE & BACKFILL WITH REUSED MATERIAL

MIDWAY LANDFILL - OPTION 3 , FULL EXCAVATION
SCALE: 1" = 100'


CONCEPTUAL
ENGINEERING

NOT FOR
CONSTRUCTION

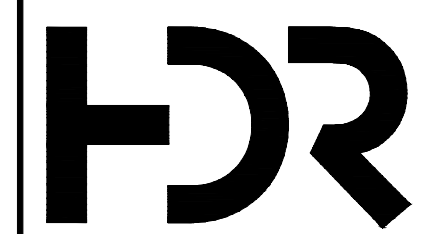
10% CONCEPTUAL ENGINEERING						DESIGNED BY: P. LOPEZ-HILFIKER					SUBMITTED BY: THOMAS MUDAYANKAVIL	DATE: March 1, 2021	REVIEWED BY:	DATE: March 1, 2021		SCALE: 1"=100'	SOUND TRANSIT OPERATIONS & MAINTENANCE FACILITY SOUTH CONCEPTUAL ENGINEERING MIDWAY LANDFILL - OPTION 3 GENERAL SITE SECTION		DRAWING No.: M06A-GSX301	
						FILENAME: DEIS_OMFS-M06A-GSX001	FACILITY ID:													
CONTRACT No.:	SHEET No.:																			
DATE:	REV:																			
No.		DATE	DSN	CHK	APP	REVISION	P. LOPEZ-HILFIKER									8				

01/27/21 | 2:16 PM | PLOPEZHILF
C:\PWORKING\WEST01\1D1861911\DEIS_OMFS-M06A-GSX001.DWG


01/19/21 | 9:41 AM | PLOPEZHILF
C:\PWORKING\WEST01\181861911\OMFS-M06A-CGX301.DWG

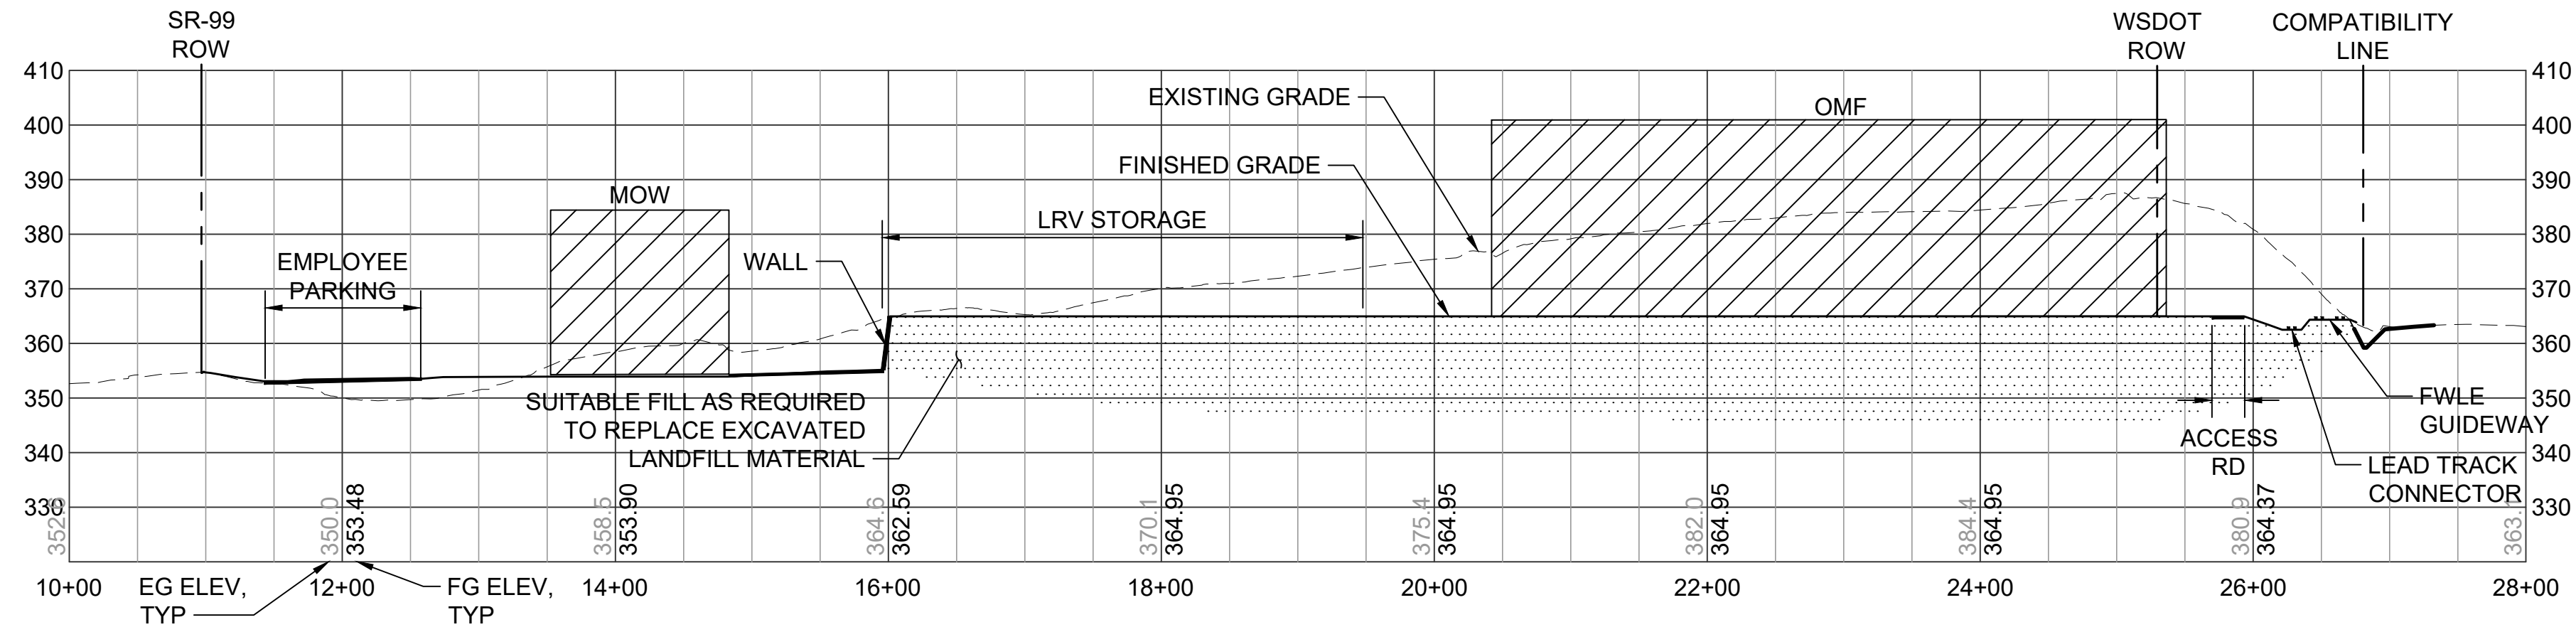


SECTION A
M06A-ASP001

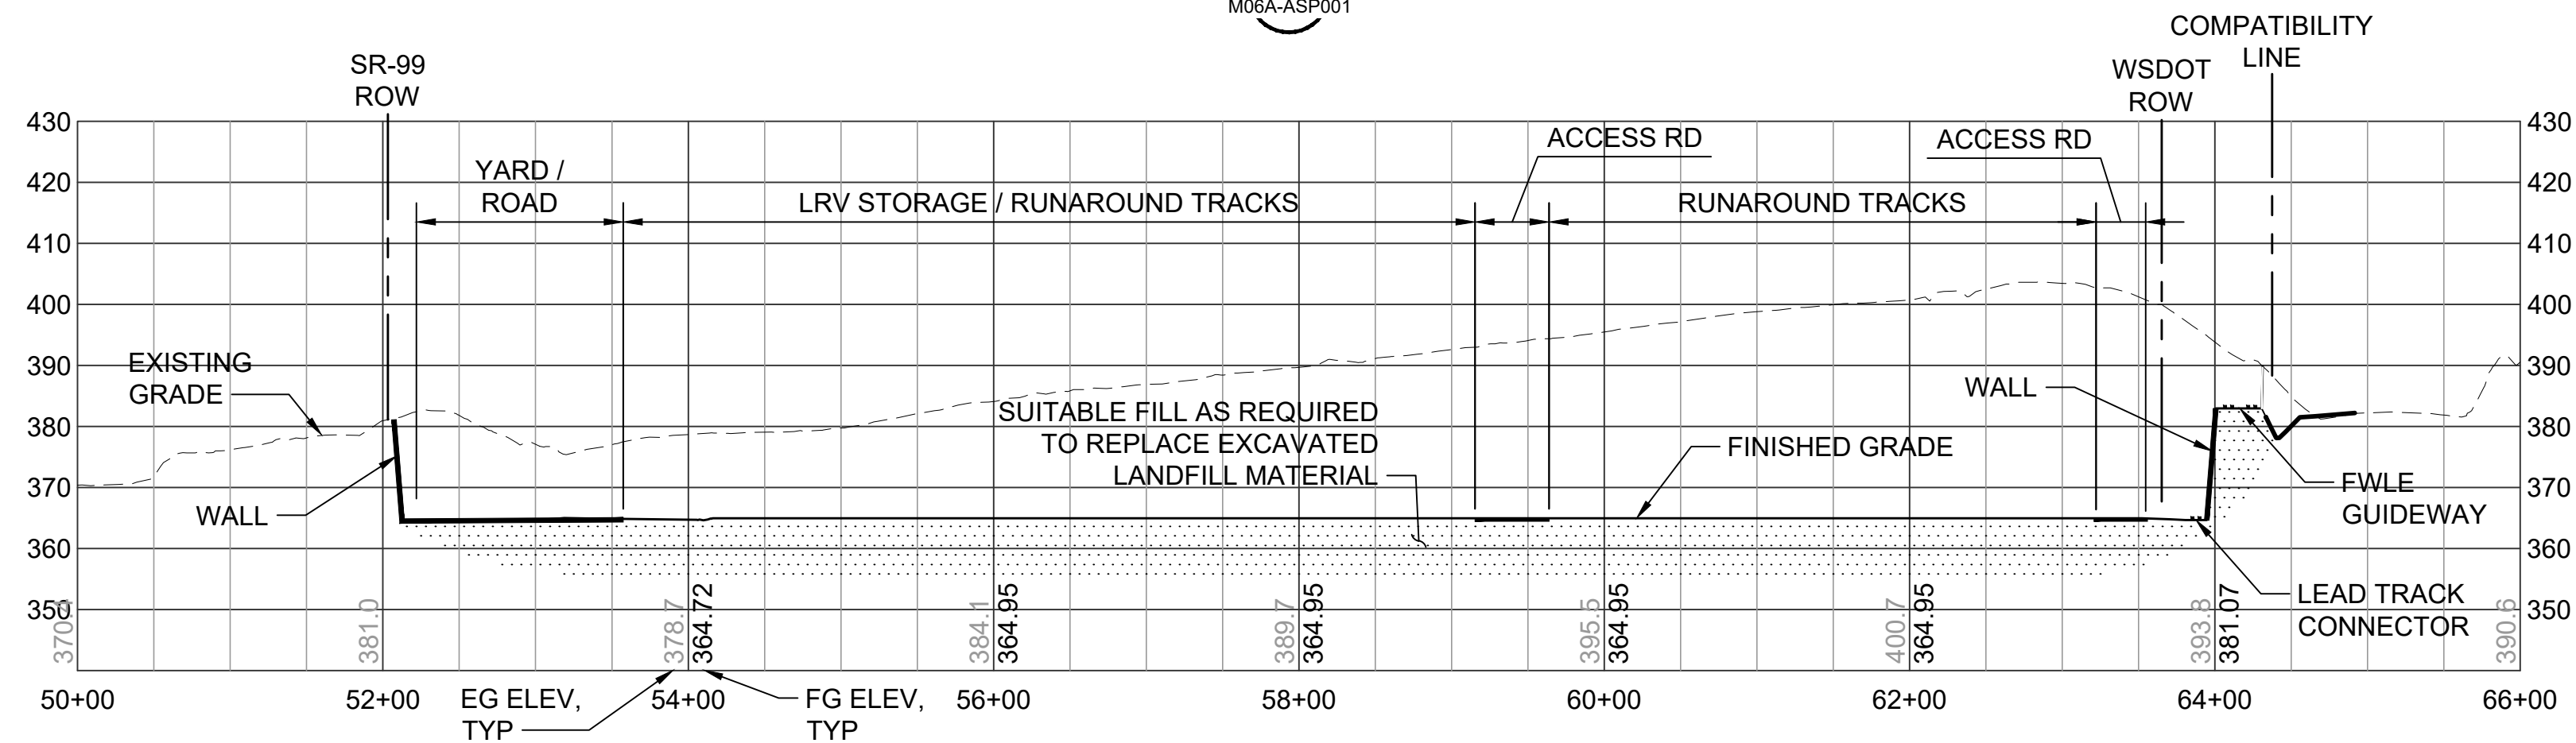

SECTION B
M06A-ASP001

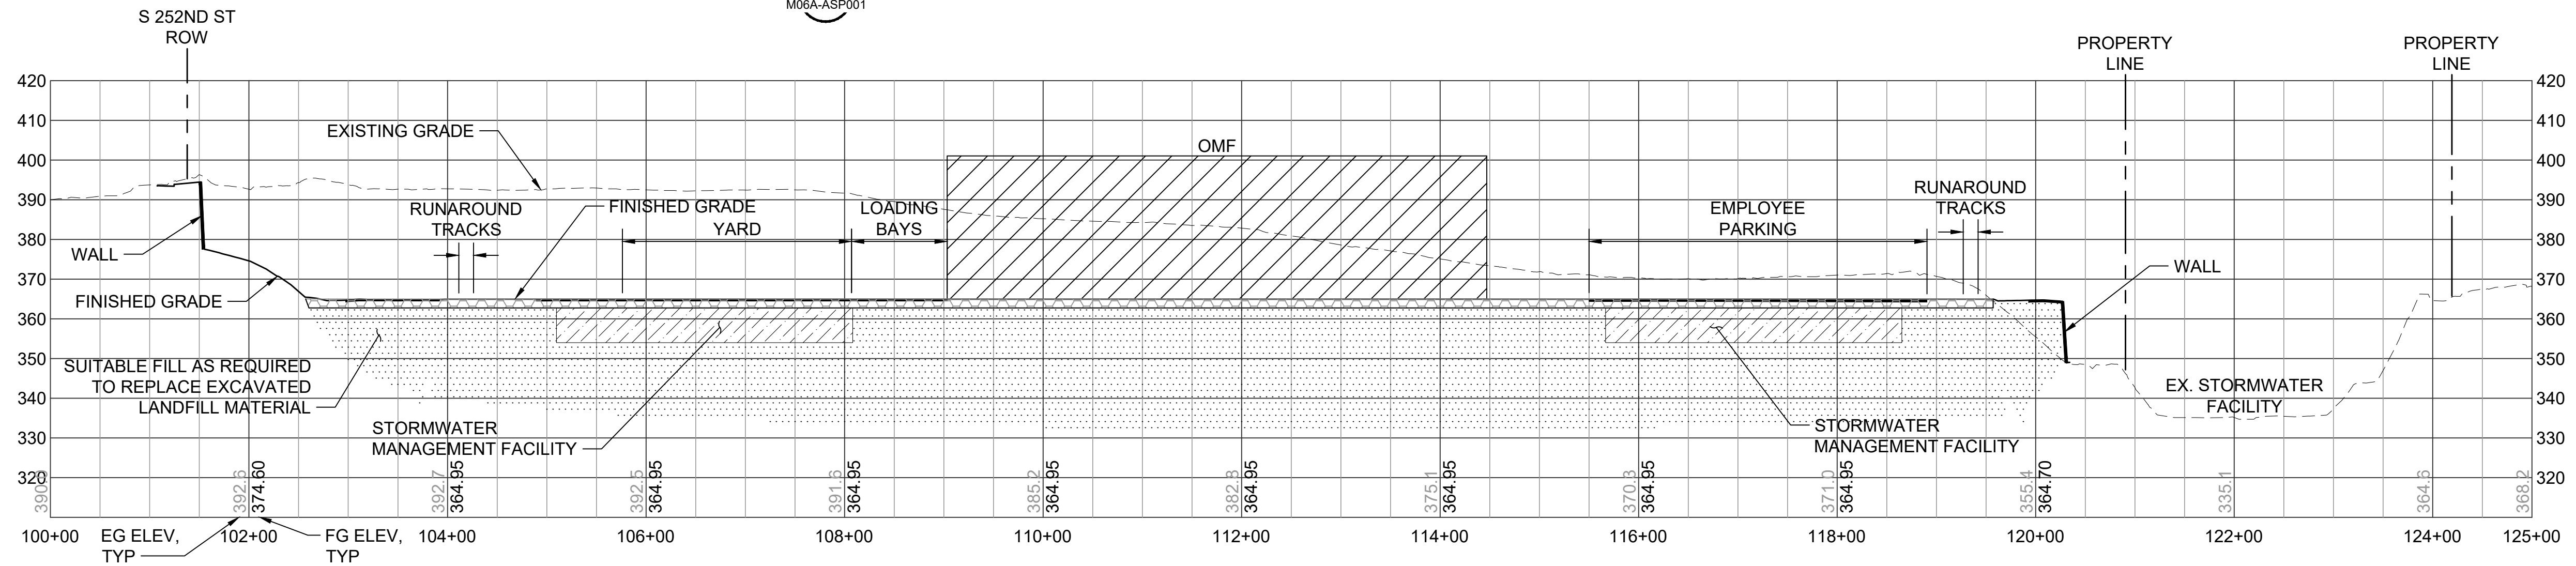

SECTION C
M06A-ASP001

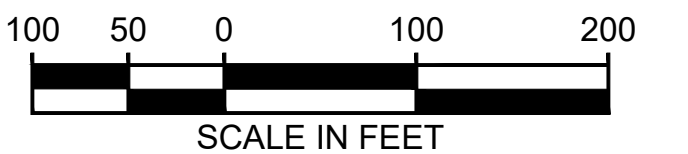


CONCEPTUAL
ENGINEERING

NOT FOR
CONSTRUCTION

10% CONCEPTUAL ENGINEERING

No.	DATE	DSN	CHK	APP	REVISION

DESIGNED BY:
P. LOPEZ-HILFIKER
DRAWN BY:
P. LOPEZ-HILFIKER
CHECKED BY:
J. HARPER
APPROVED BY:
P. LOPEZ-HILFIKER

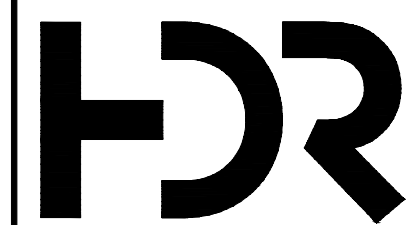

SUBMITTED BY:
THOMAS MUDAYANKAVIL

DATE:
MARCH 1, 2021

REVIEWED BY:

LINE IS "AT"
FULL SCALE





SCALE:
1"=100'
FILENAME:
OMFS-M06A-CGX301
CONTRACT No.:

DATE:
MARCH 1, 2021

SOUND TRANSIT
OPERATIONS & MAINTENANCE FACILITY SOUTH
CONCEPTUAL ENGINEERING
MIDWAY LANDFILL - OPTION 3
GRADING CROSS SECTIONS

DRAWING No.:
M06A-CGX301
FACILITY ID:
SHEET No.:
REV:
9

02/15/21 | 9:58 AM | PLOPEZHILF
C:\P\WORKING\WEST01D\86191\IDEIS_OMFS-S08A-KAP000.DWG

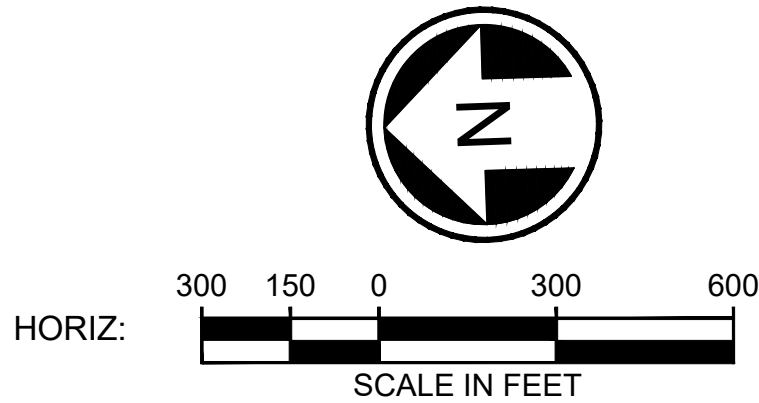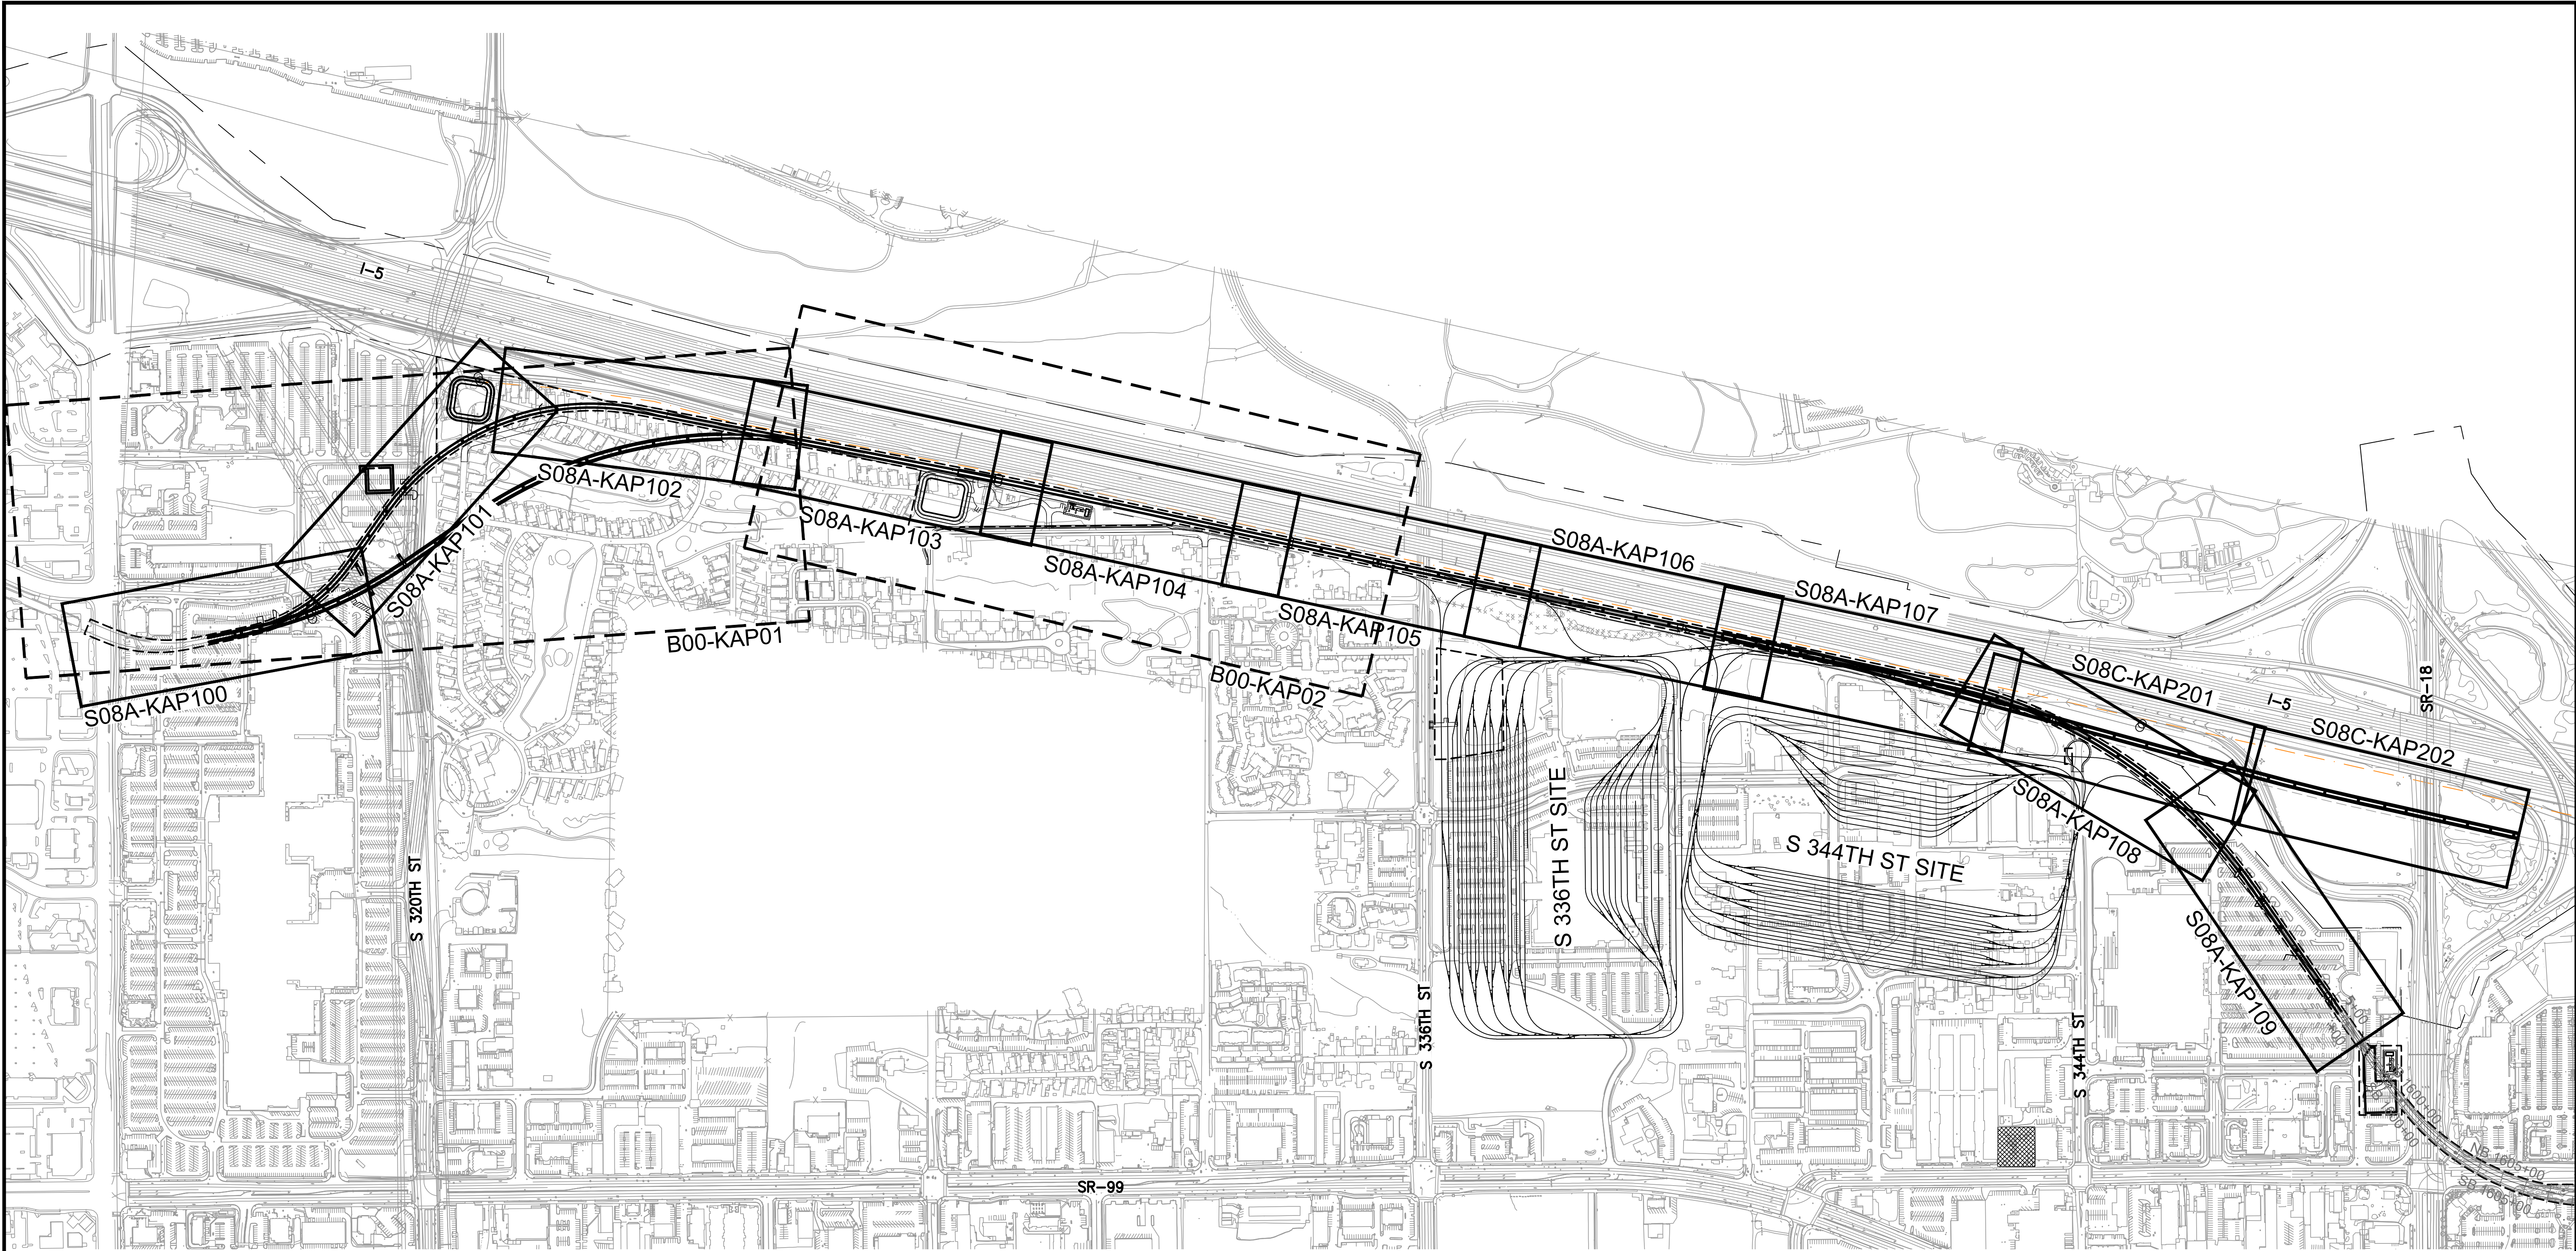


CONCEPTUAL
ENGINEERING

NOT FOR
CONSTRUCTION

10% CONCEPTUAL ENGINEERING

No.	DATE	DSN	CHK	APP	REVISION

DESIGNED BY: H. LIU
DRAWN BY: J. TYLER
CHECKED BY: M. PETERSON
APPROVED BY: T. MUDAYANKAVIL

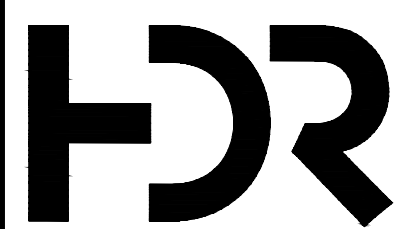

SUBMITTED BY:
THOMAS MUDAYANKAVIL

DATE:
MARCH 1, 2021

REVIEWED BY:

LINE IS 1" AT
FULL SCALE




DATE:
MARCH 1, 2021

SCALE: NTS
FILENAME:
CONTRACT No.:
DATE:

SOUND TRANSIT
OPERATIONS & MAINTENANCE FACILITY SOUTH
CONCEPTUAL ENGINEERING


TDLE MAINLINE FOR OMFS
TRACK KEY MAP

DRAWING No.:	S08A-KAP000
FACILITY ID:	
SHEET No.:	10
REV:	

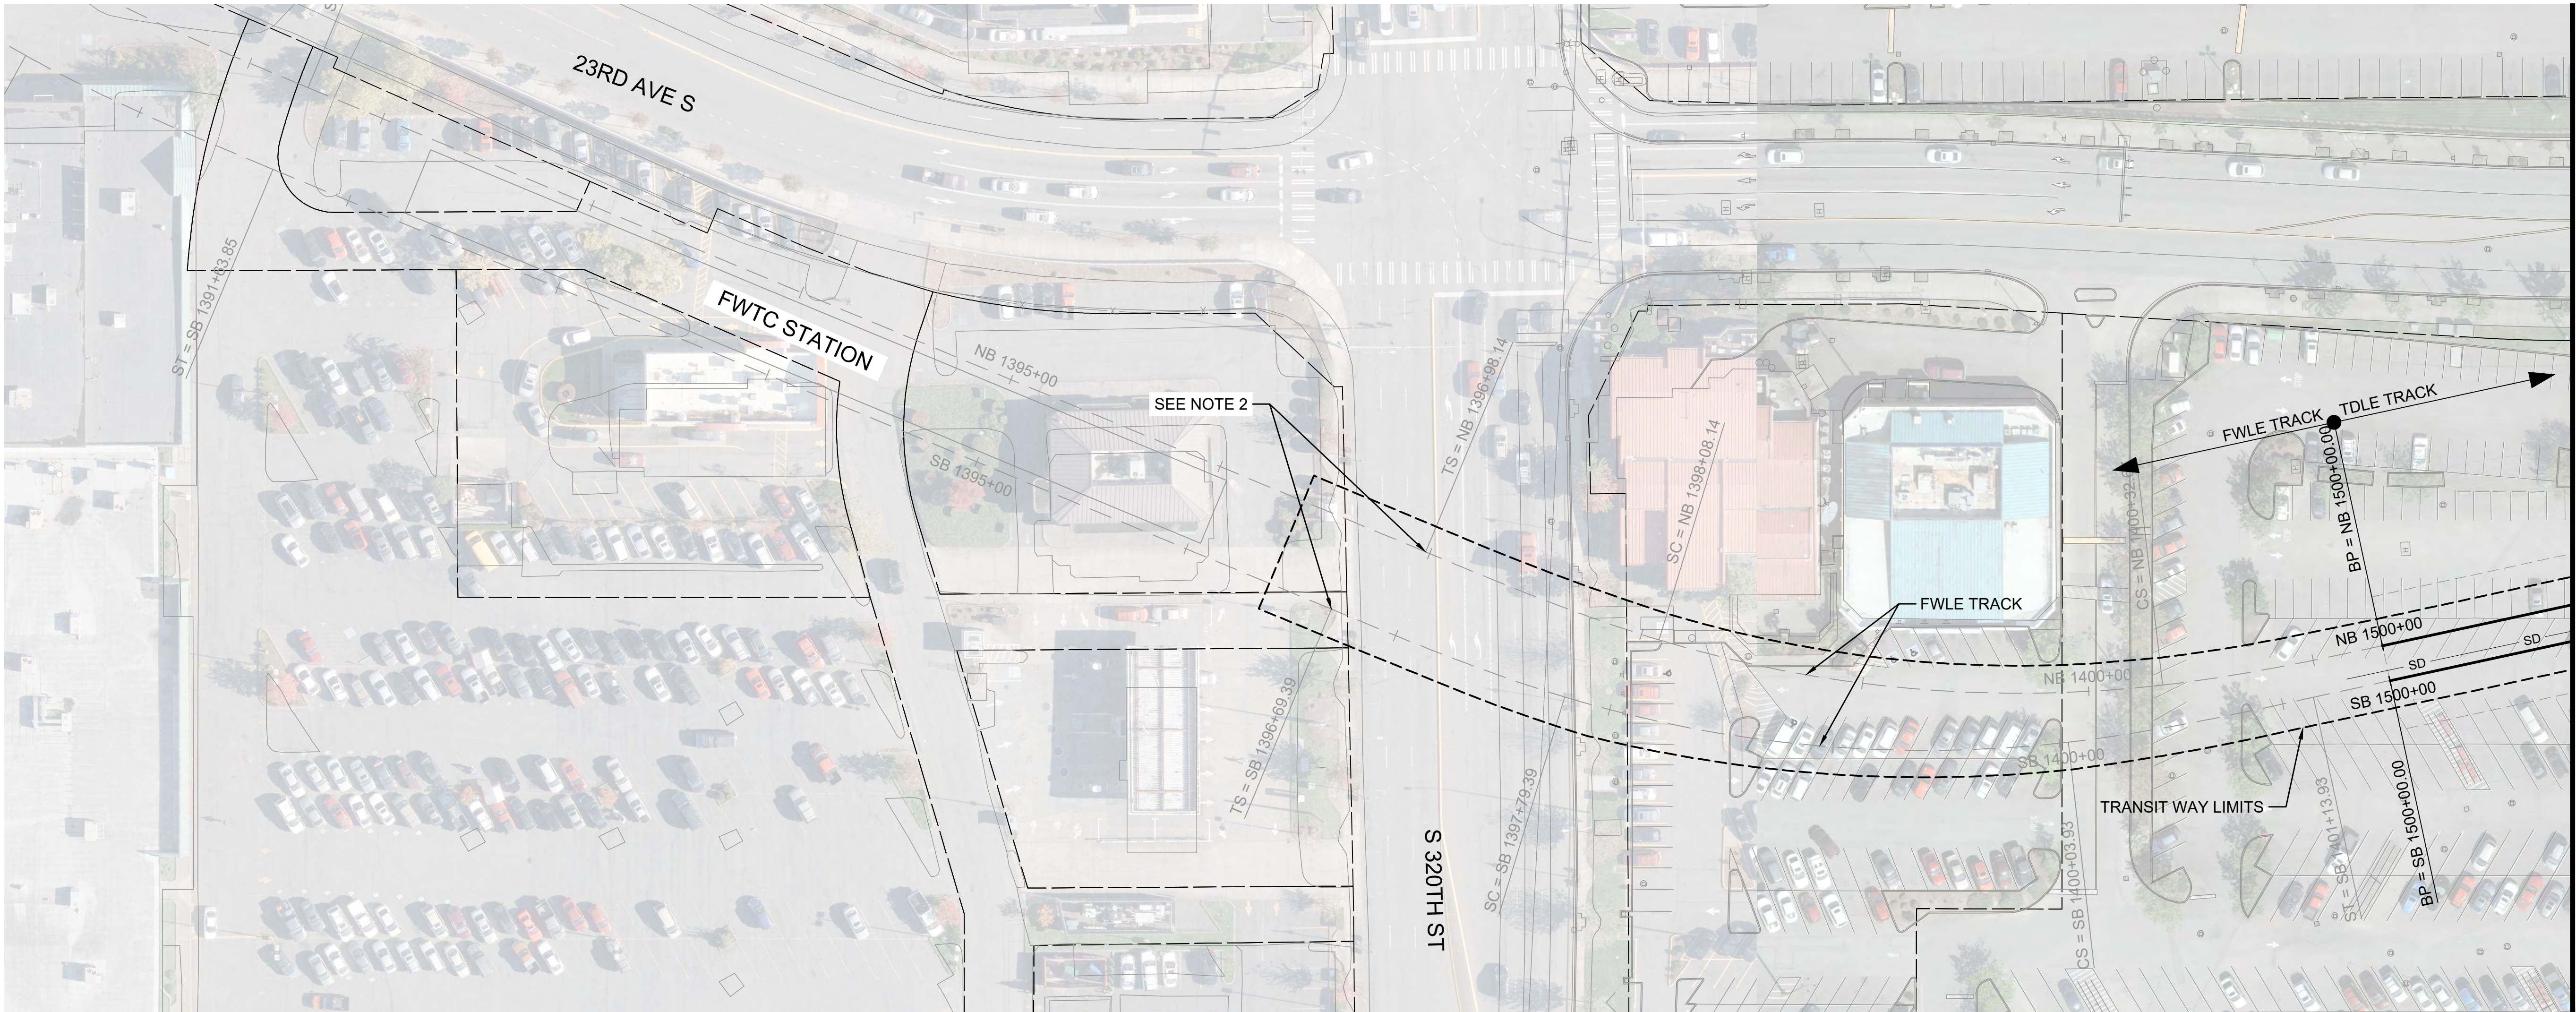

SEE DWG S08A-KAP101

- NOTES:**
- 1. FWLE ALIGNMENT SHOWN IS BASED OFF OF 60% DESIGN. TDLE DESIGN WILL BE UPDATED TO TIE INTO FWLE 90% WHEN AVAILABLE.
 - 2. FWLE INTERIM TAIL TRACKS ARE ON HORIZONTAL CURVES DESIGNED WITH NO SUPERELEVATION. TDLE WILL NEED TO RECONSTRUCT THESE CURVES WITH Ea= 3.50", Eu= 2.98", AND 30 MPH DESIGN SPEED.

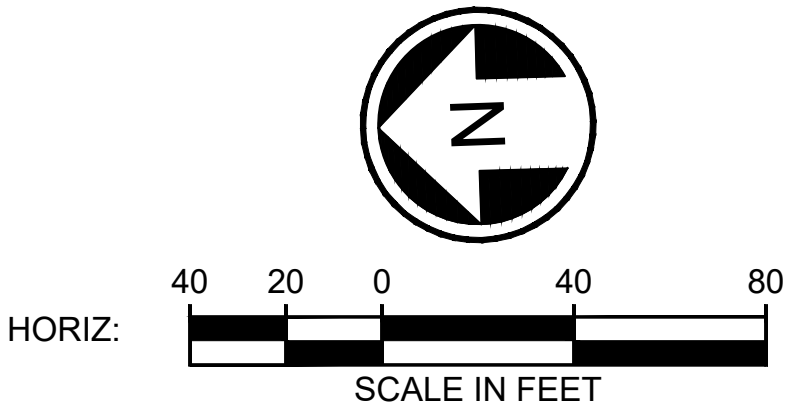


CONCEPTUAL
ENGINEERING

NOT FOR
CONSTRUCTION

10% CONCEPTUAL ENGINEERING

No.	DATE	DSN	CHK	APP	REVISION

DESIGNED BY: H. LIU
DRAWN BY: J. TYLER
CHECKED BY: M. PETERSON
APPROVED BY: T. MUDAYANKAVIL

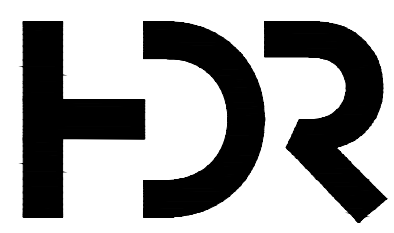

SUBMITTED BY: THOMAS MUDAYANKAVIL	DATE: MARCH 1, 2021	REVIEWED BY:	DATE: MARCH 1, 2021
--------------------------------------	------------------------	--------------	------------------------


LINE IS 1" AT
FULL SCALE

SCALE: 1"=40'
FILENAME:
CONTRACT No.:
DATE:

SOUND TRANSIT
OPERATIONS & MAINTENANCE FACILITY SOUTH
CONCEPTUAL ENGINEERING

TDLE MAINLINE FOR OMFS
TRACK PLAN AND PROFILE
S FEDERAL WAY ENCHANTED PKWY

DRAWING No.:	
S08A-KAP100	
FACILITY ID:	
SHEET No.:	REV:
11	

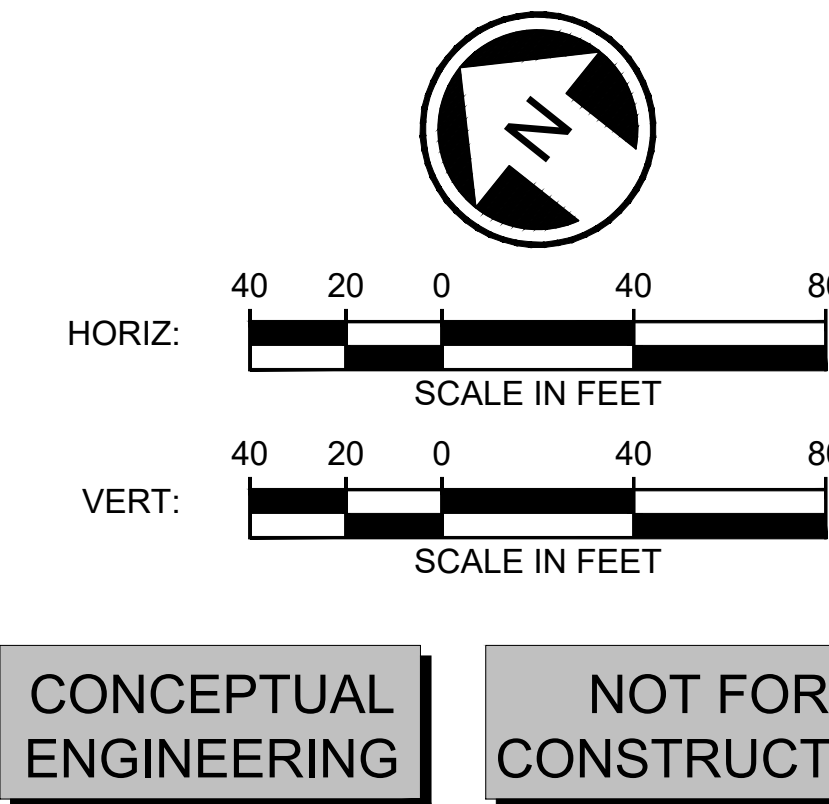

No.	DATE	DSN	CHK	APP	REVISION

SUBMITTED BY:
THOMAS MUDAYANKAVIL

REVIEWED BY:




SCALE:	1"=40'
FILENAME:	
CONTRACT No.:	
DATE:	


DRAWING No.:	
S08A-KAP101	
FACILITY ID:	
SHEET No.:	REV:
12	

01/20/21 | 2:32 PM | PLOPEZHILF
C:\PWORKING\WEST01D1861911\OMFS-S08A-KAP100-109.DWG

SEE DWG S08A-KAP101

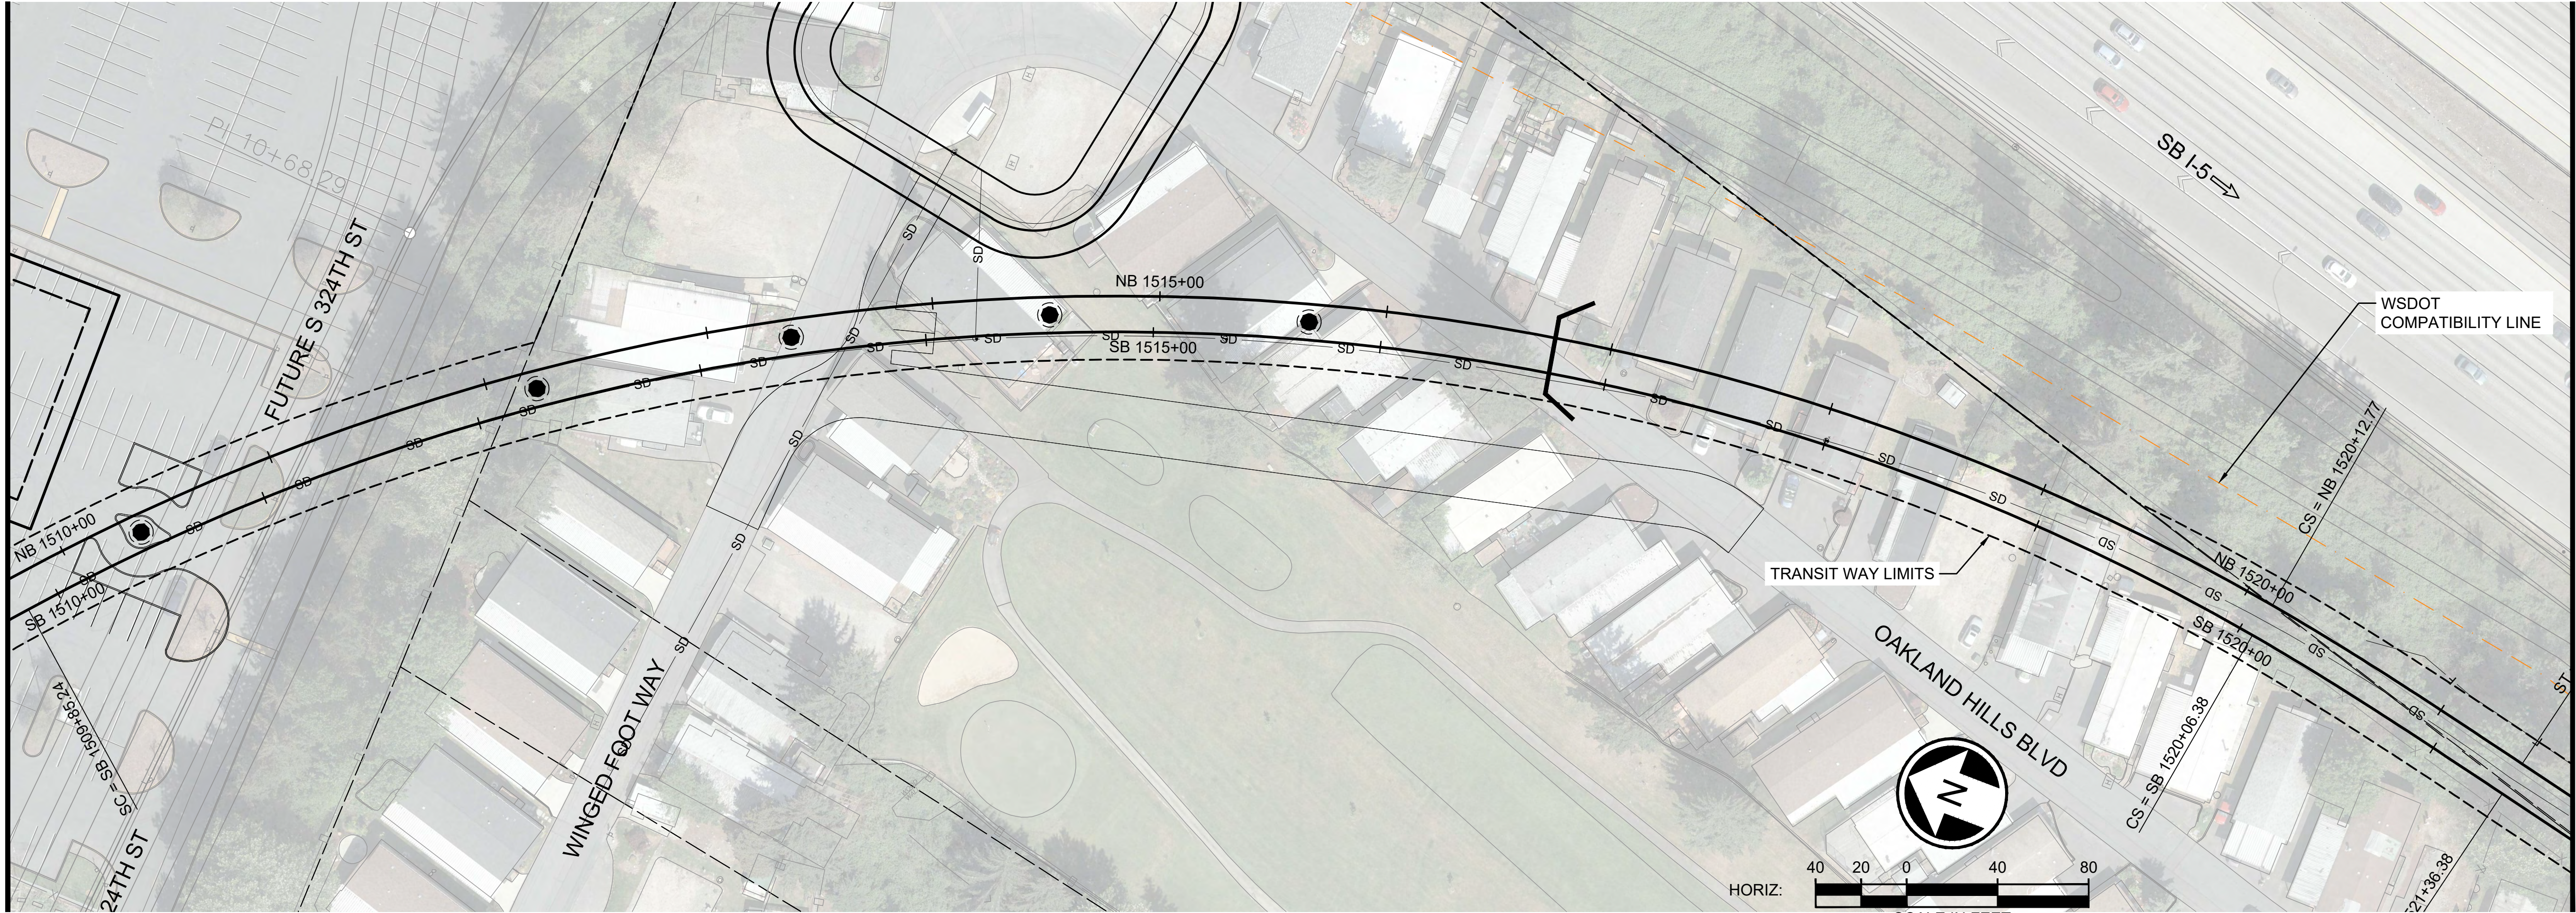

SEE DWG S08A-KAP103

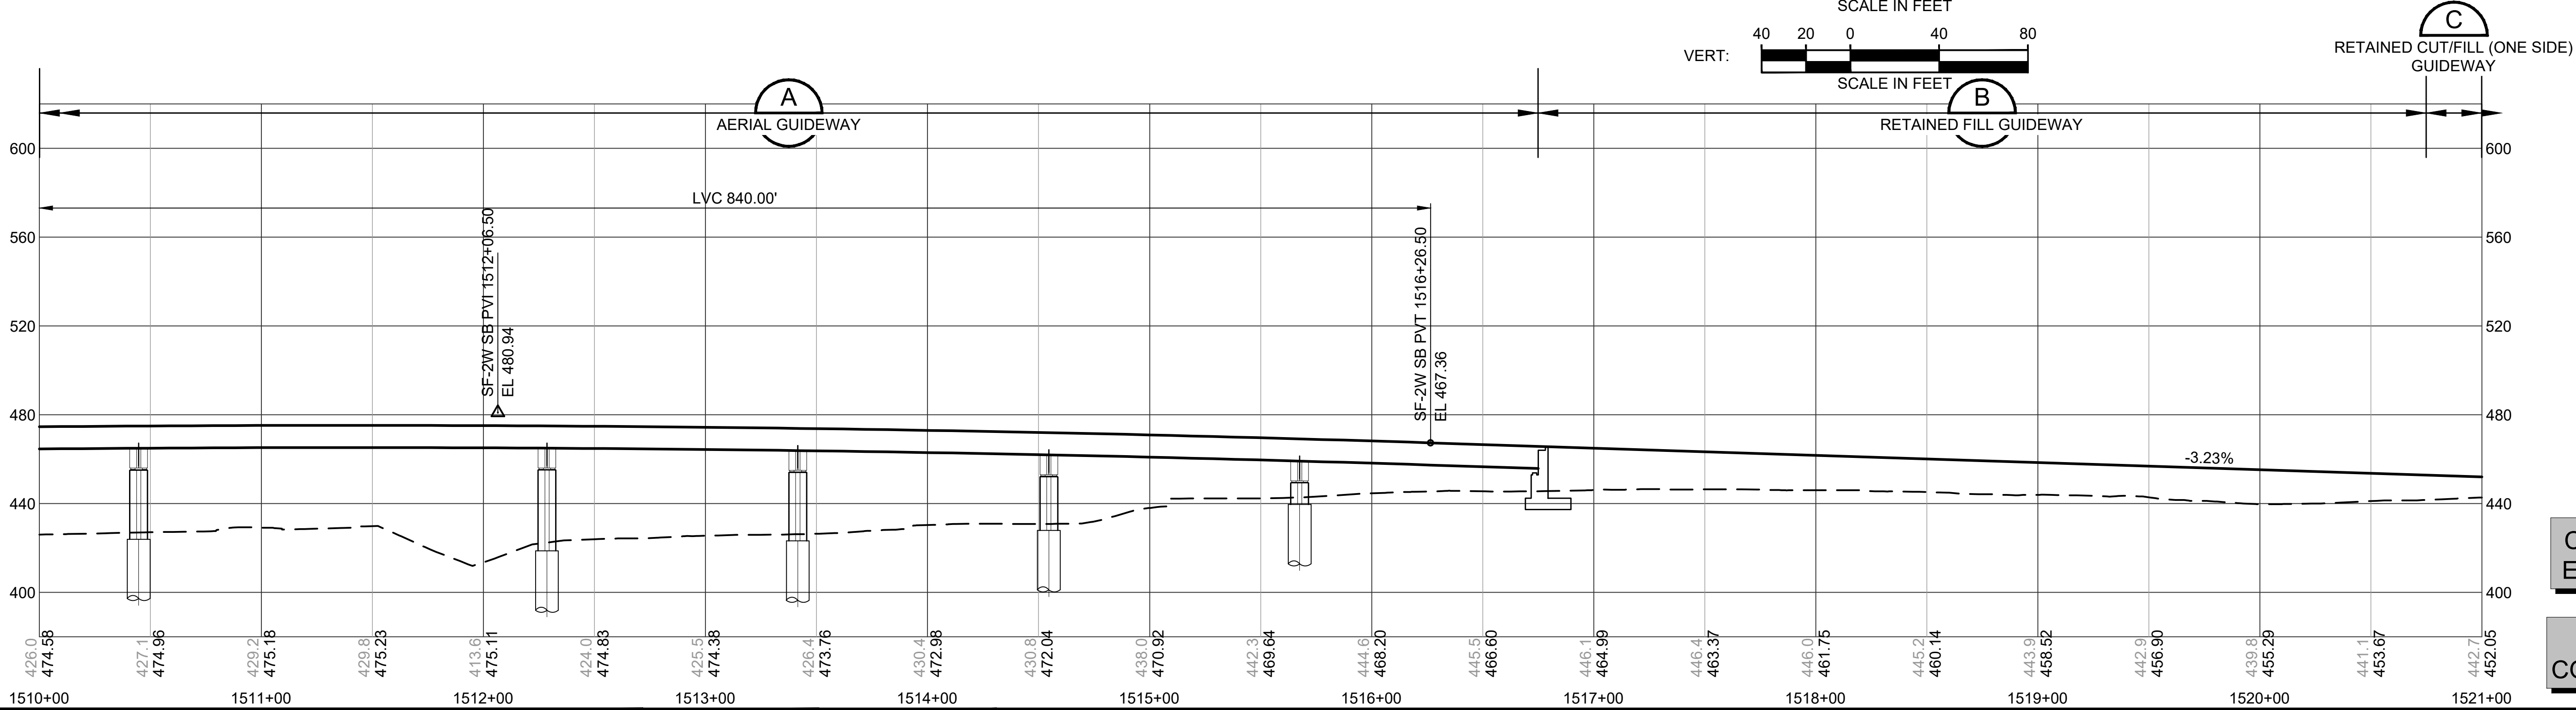


CONCEPTUAL
ENGINEERING

NOT FOR
CONSTRUCTION

10% CONCEPTUAL ENGINEERING

DESIGNED BY:
H. LIU
DRAWN BY:
J. TYLER
CHECKED BY:
M. PETERSON
APPROVED BY:
T. MUDAYANKAVIL

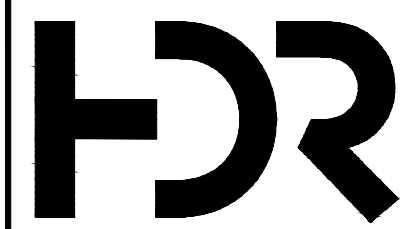

SUBMITTED BY:
THOMAS MUDAYANKAVIL

DATE:
MARCH 1, 2021

REVIEWED BY:

LINE IS 1" AT
FULL SCALE



DATE:
MARCH 1, 2021

SCALE:
1"=40'
FILENAME:
CONTRACT No.:
DATE:



SOUND TRANSIT
OPERATIONS & MAINTENANCE FACILITY SOUTH
CONCEPTUAL ENGINEERING
TDLE MAINLINE FOR OMFS
TRACK PLAN AND PROFILE
S FEDERAL WAY ENCHANTED PKWY

DRAWING No.:
S08A-KAP102
FACILITY ID:
SHEET No.:
REV:
13

01/20/21 | 2:33 PM | PLOPEZHILF
C:\PWORKING\WEST01D1861911\OMFS-S08A-KAP100-109.DWG

SEE DWG S08A-KAP102

SEE DWG S08A-KAP104

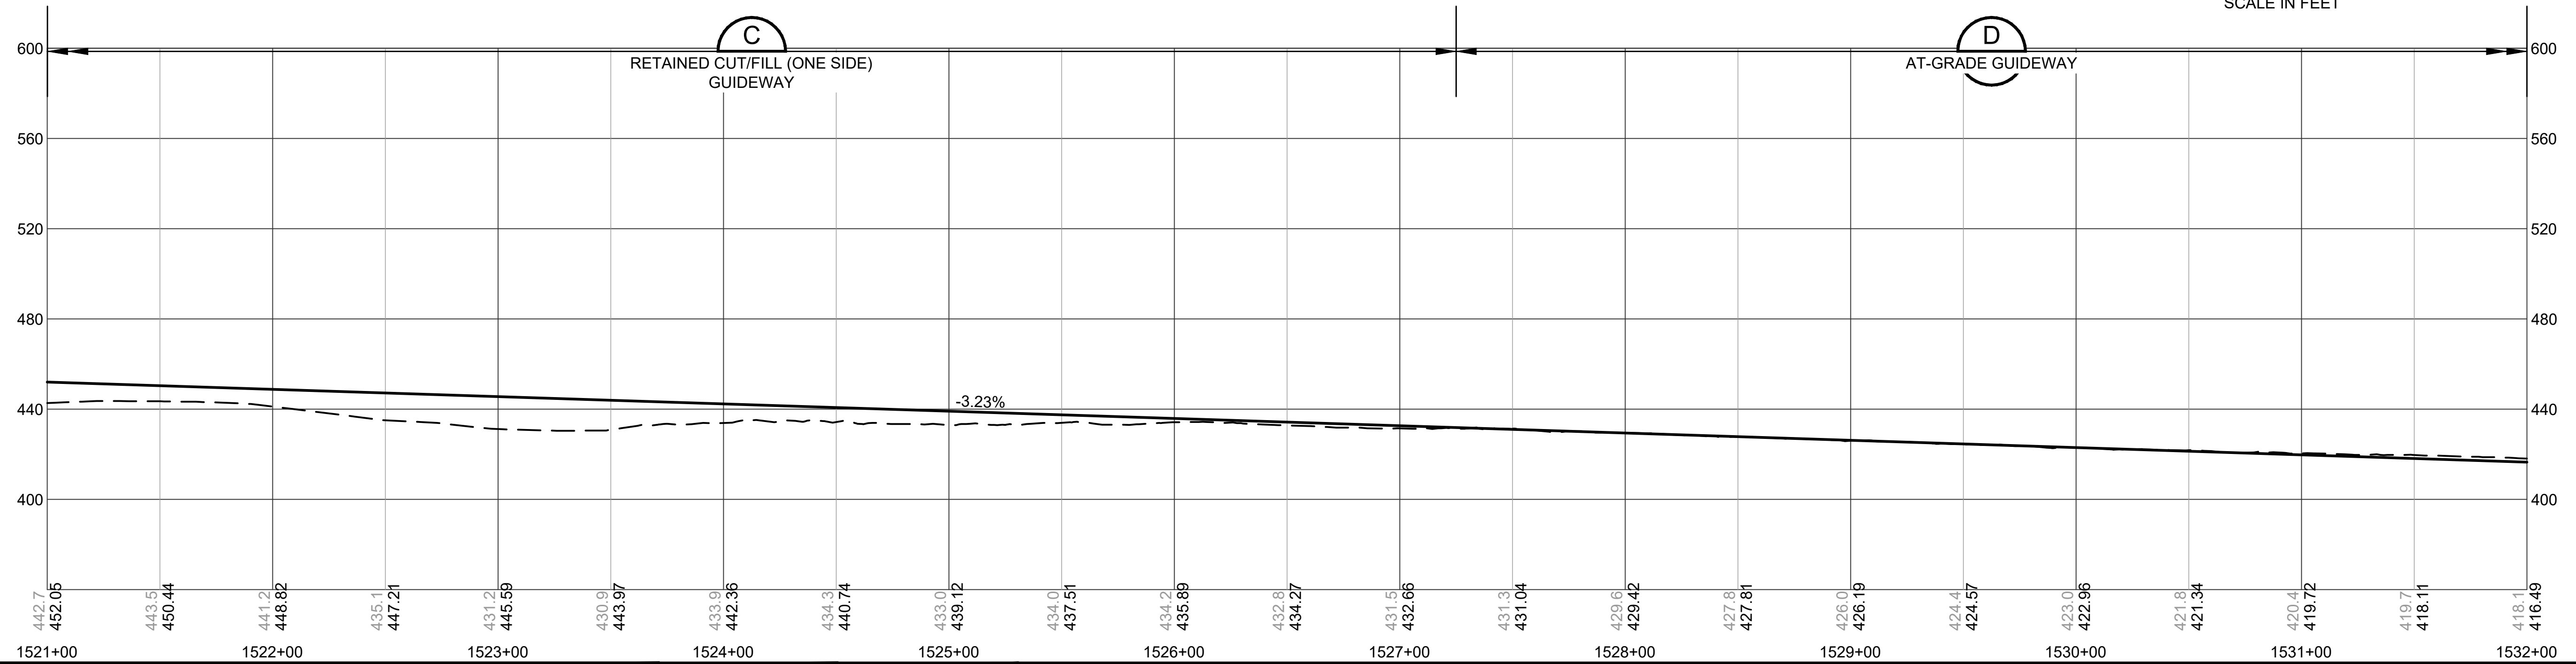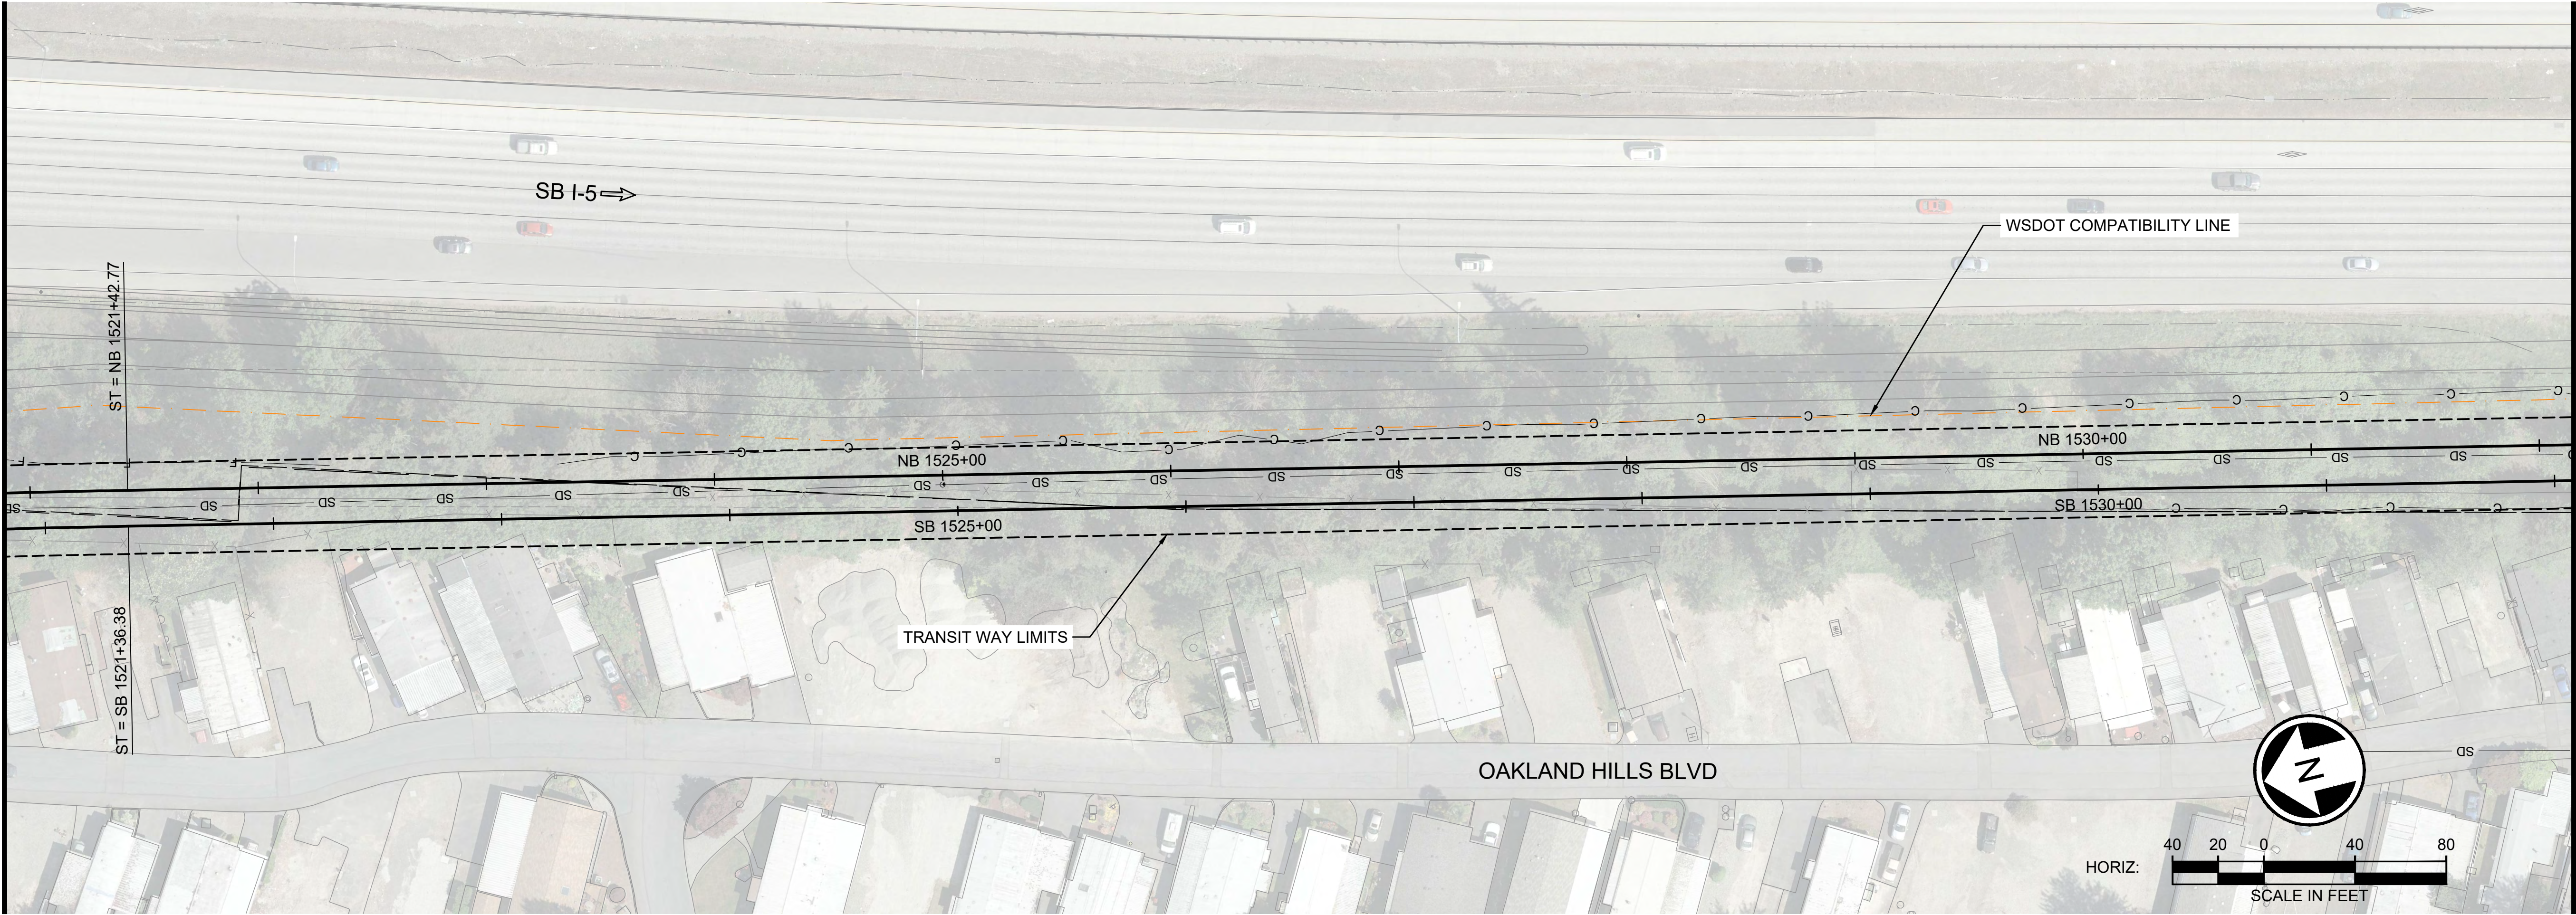


CONCEPTUAL
ENGINEERING

NOT FOR
CONSTRUCTION

10% CONCEPTUAL ENGINEERING					
No.	DATE	DSN	CHK	APP	REVISION

DESIGNED BY:	H. LIU
DRAWN BY:	J. TYLER
CHECKED BY:	M. PETERSON
APPROVED BY:	T. MUDAYANKAVIL

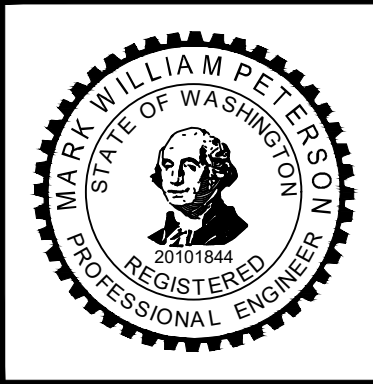

SUBMITTED BY:
THOMAS MUDAYANKAVIL

DATE:
MARCH 1, 2021

REVIEWED BY:

LINE IS 1" AT
FULL SCALE

SCALE: 1"=40'
FILENAME:
CONTRACT No.:
DATE:


SOUND TRANSIT
OPERATIONS & MAINTENANCE FACILITY SOUTH
CONCEPTUAL ENGINEERING

TDL MAINLINE FOR OMFS
TRACK PLAN AND PROFILE
S FEDERAL WAY ENCHANTED PKWY



DRAWING No.:	S08A-KAP103
FACILITY ID:	
SHEET No.:	REV:
14	

01/20/21 | 2:33 PM | PLOPEZHILF
C:\PWORKING\WEST01D1861911\QMFS-S08A-KAP100-109.DWG

SEE DWG S08A-KAP103

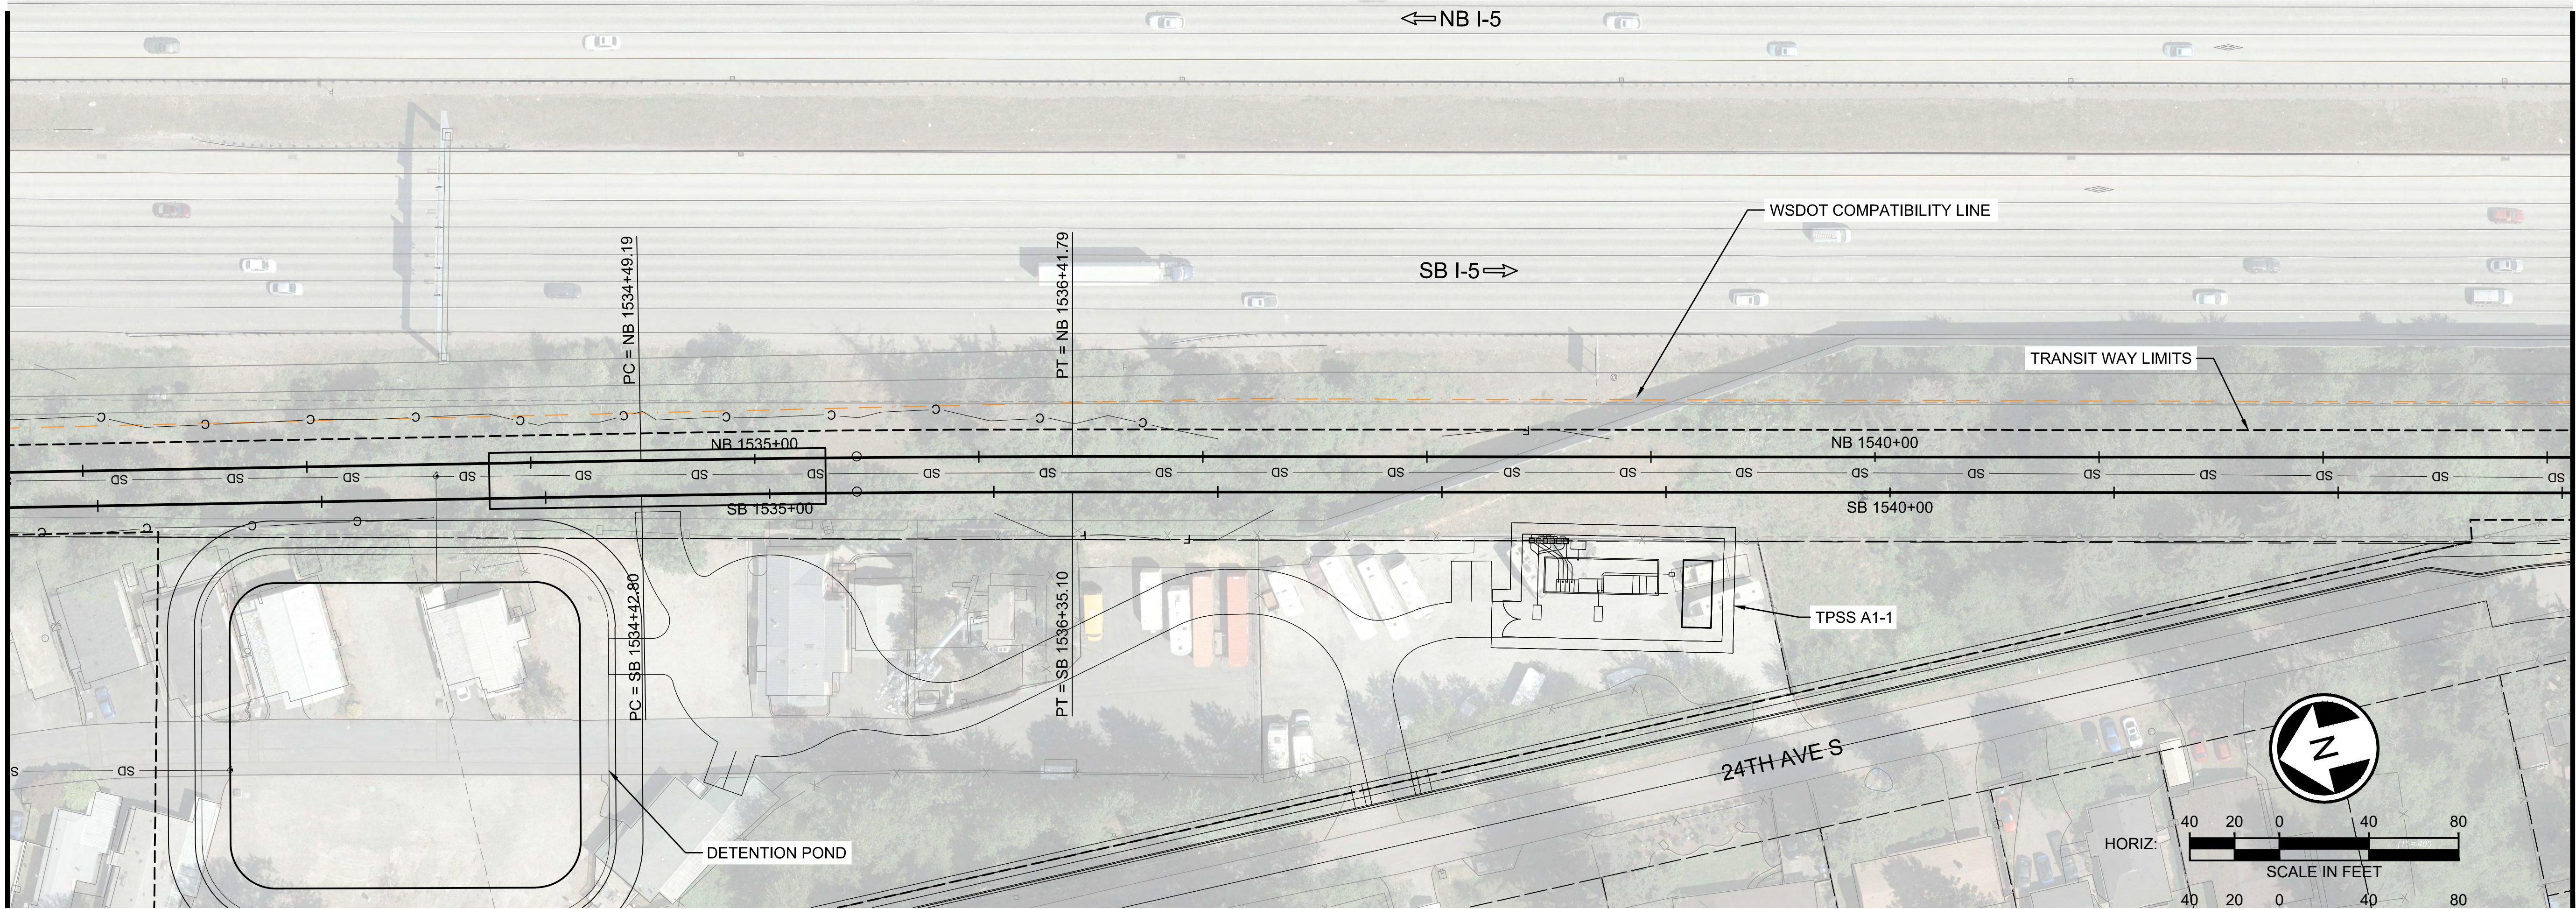

SEE DWG S08A-KAP105

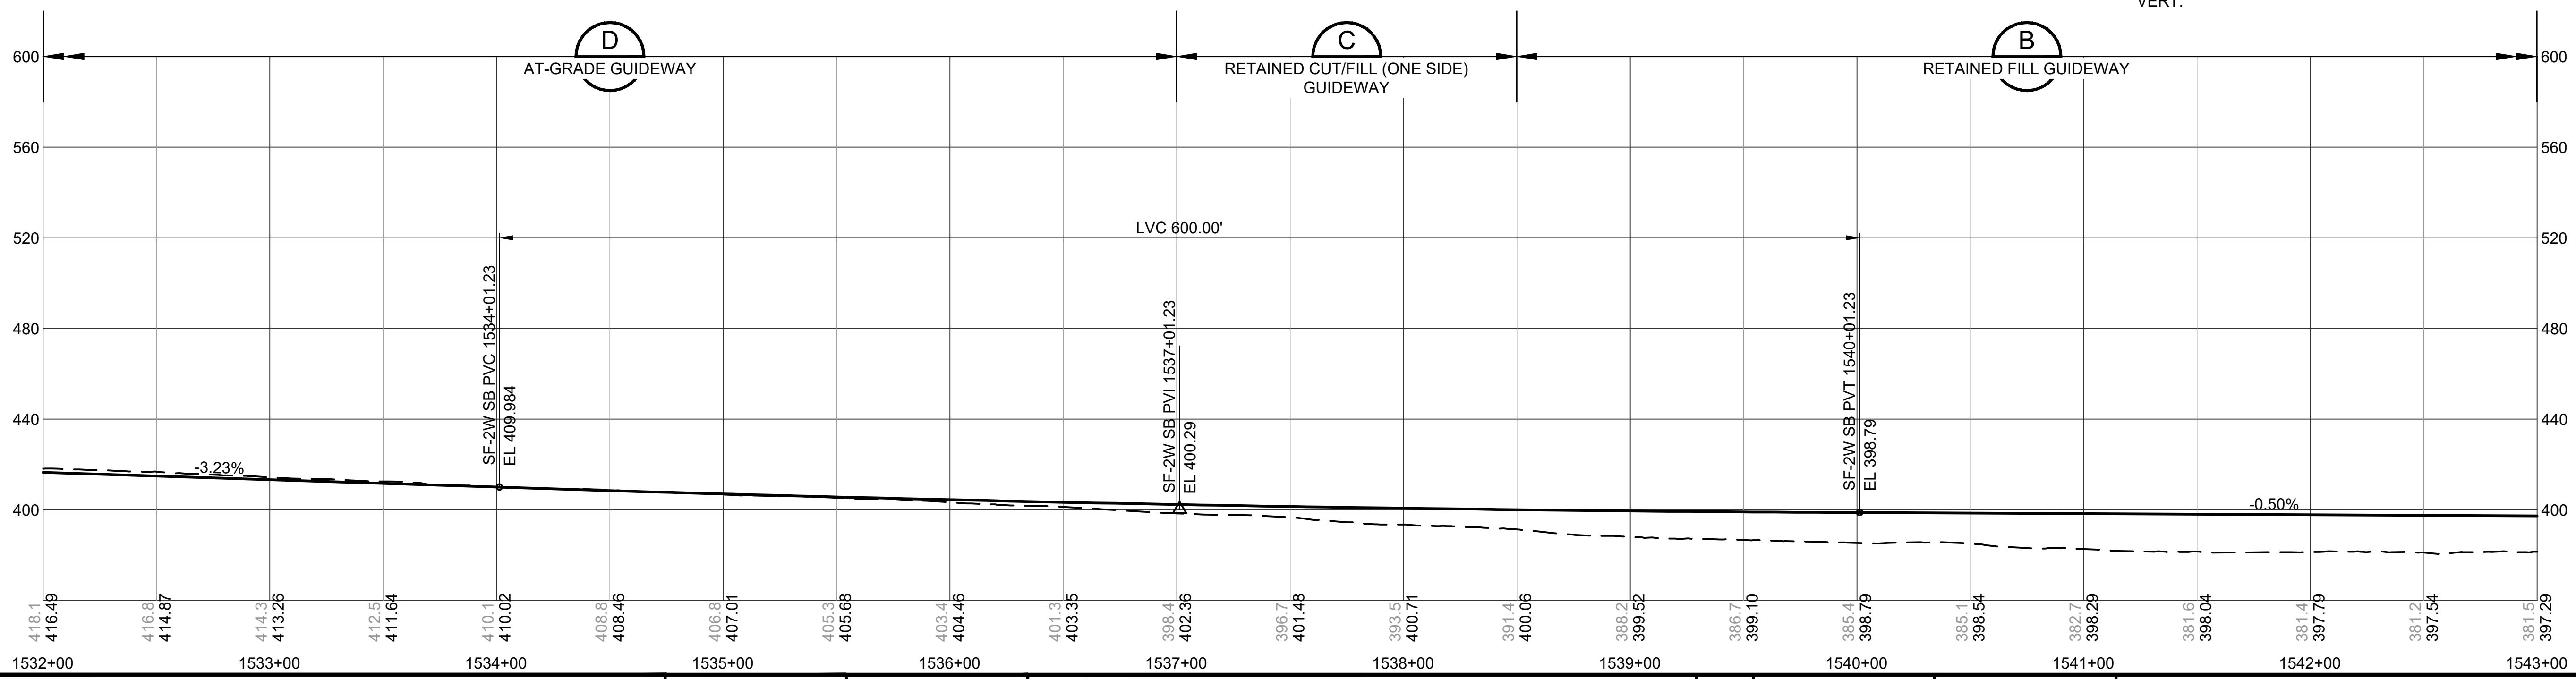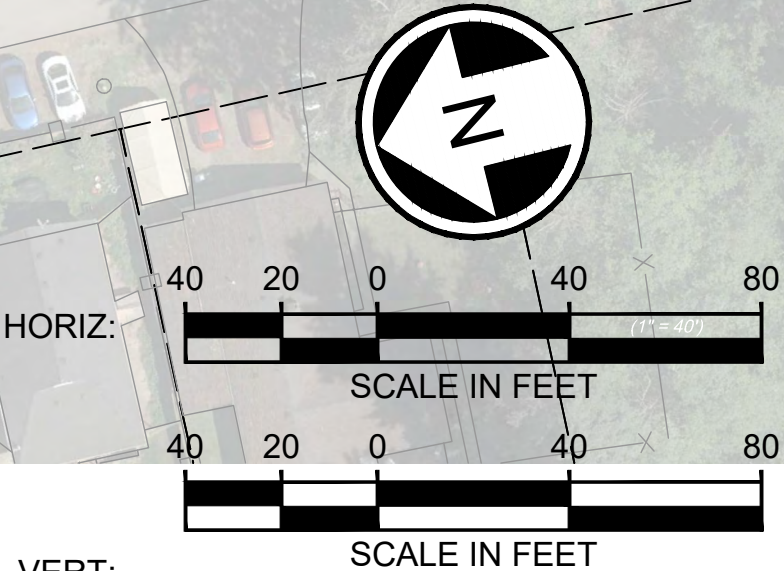


CONCEPTUAL
ENGINEERING

NOT FOR
CONSTRUCTION

10% CONCEPTUAL ENGINEERING

DESIGNED BY:
H. LIU
DRAWN BY:
J. TYLER
CHECKED BY:
M. PETERSON
APPROVED BY:
T. MUDAYANKAVIL

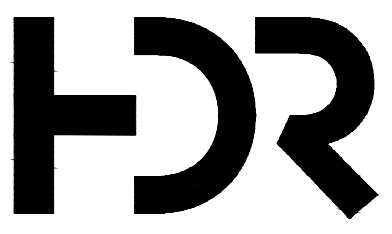

SUBMITTED BY:
THOMAS MUDAYANKAVIL

DATE:
MARCH 1, 2021

REVIEWED BY:



DATE:
MARCH 1, 2021

SCALE:
1"=40'
FILENAME:
CONTRACT No.:
DATE:



SOUND TRANSIT
OPERATIONS & MAINTENANCE FACILITY SOUTH
CONCEPTUAL ENGINEERING
TDLE MAINLINE FOR OMFS
TRACK PLAN AND PROFILE
S FEDERAL WAY ENCHANTED PKWY

DRAWING No.:
S08A-KAP104
FACILITY ID:
SHEET No.:
REV:
15

01/20/21 | 2:33 PM | PLOPEZHILF
C:\P\WORKING\WEST01D1861911\OMFS-S08A-KAP100-109.DWG

SEE DWG S08A-KAP104

SEE DWG S08A-KAP106

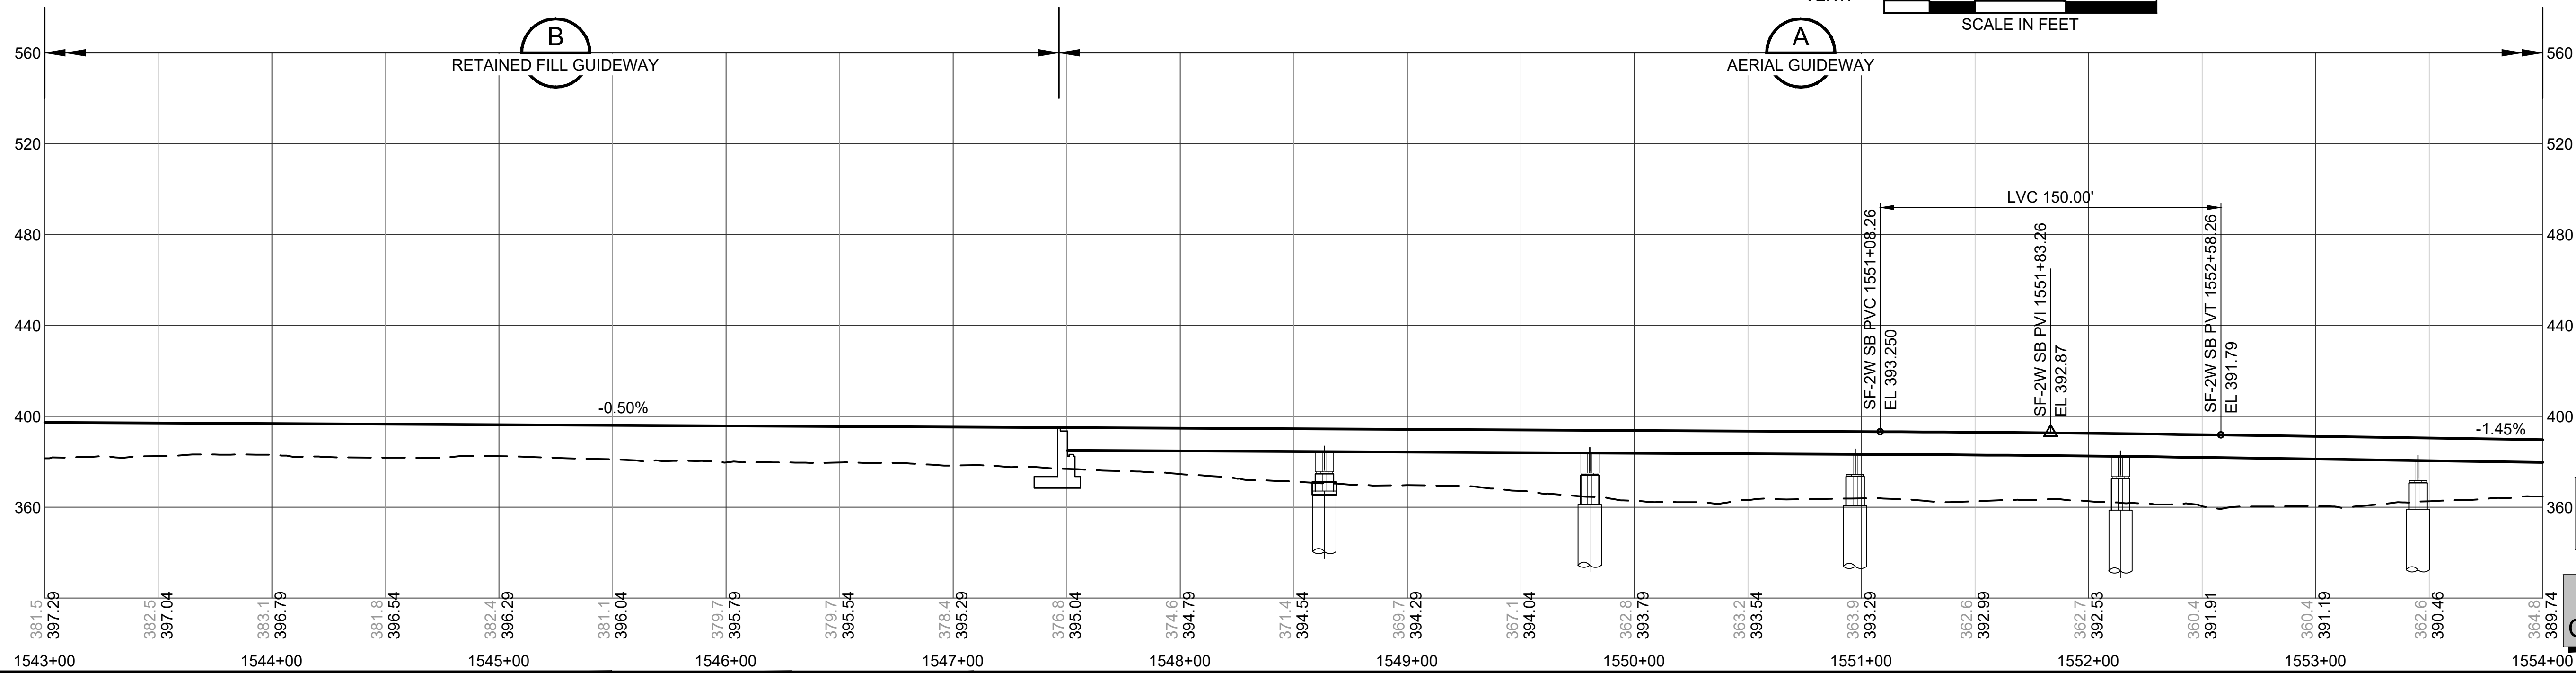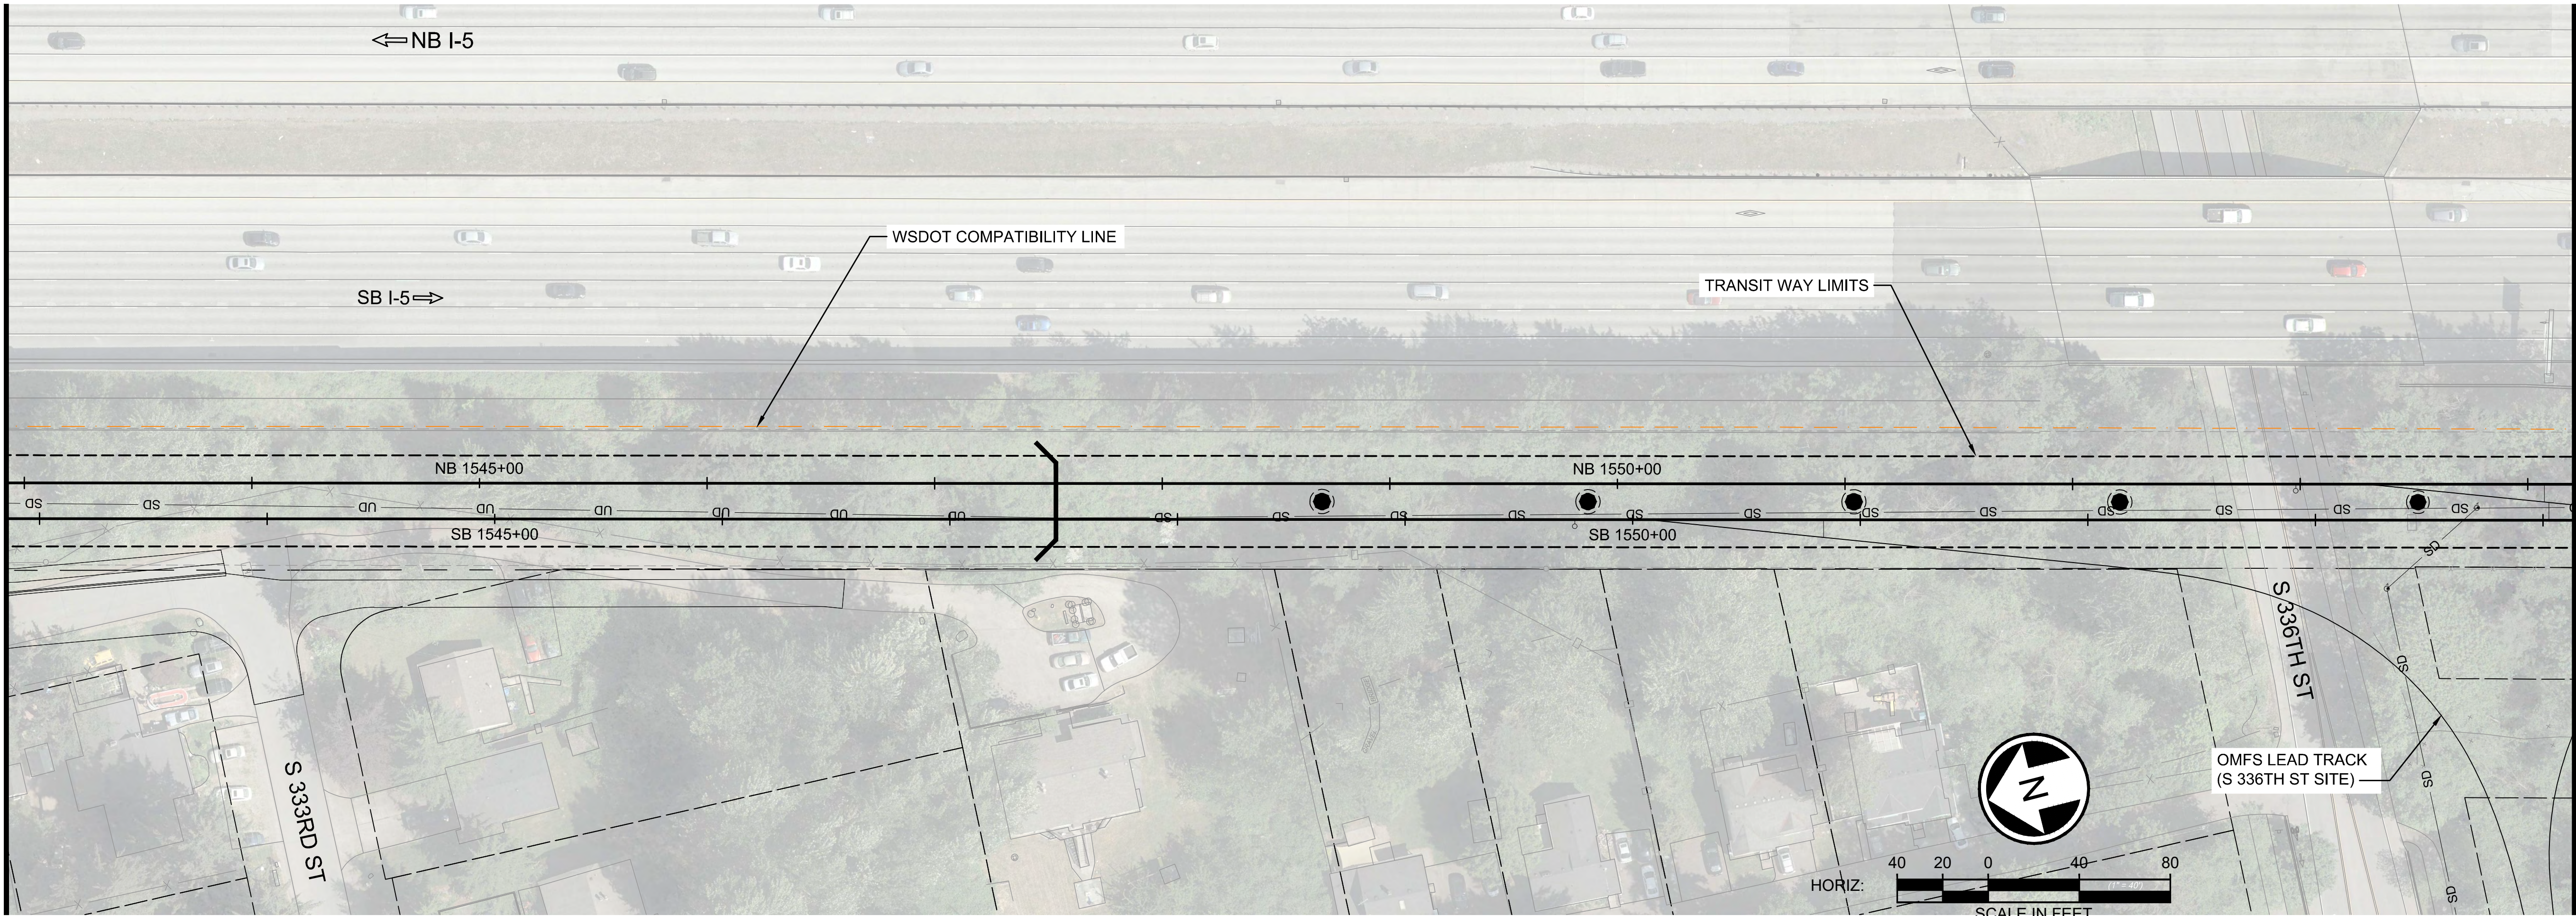


CONCEPTUAL
ENGINEERING

NOT FOR
CONSTRUCTION

10% CONCEPTUAL ENGINEERING

DESIGNED BY:
H. LIU
DRAWN BY:
J. TYLER
CHECKED BY:
M. PETERSON
APPROVED BY:
T. MUDAYANKAVIL

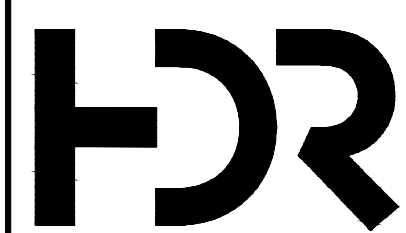

SUBMITTED BY:
THOMAS MUDAYANKAVIL

DATE:
MARCH 1, 2021

REVIEWED BY:



DATE:
MARCH 1, 2021

SCALE:
1"=40'
FILENAME:
CONTRACT No.:
DATE:


SOUND TRANSIT
OPERATIONS & MAINTENANCE FACILITY SOUTH
CONCEPTUAL ENGINEERING
TDLE MAINLINE FOR OMFS
TRACK PLAN AND PROFILE
S FEDERAL WAY ENCHANTED PKWY

DRAWING No.:
S08A-KAP105
FACILITY ID:
SHEET No.:
REV:
16

01/20/21 | 2:34 PM | PLOPEZHILF
C:\P\WORKING\WEST01D1861911\OMFS-S08A-KAP100-109.DWG

SEE DWG S08A-KAP105


SEE DWG S08A-KAP107

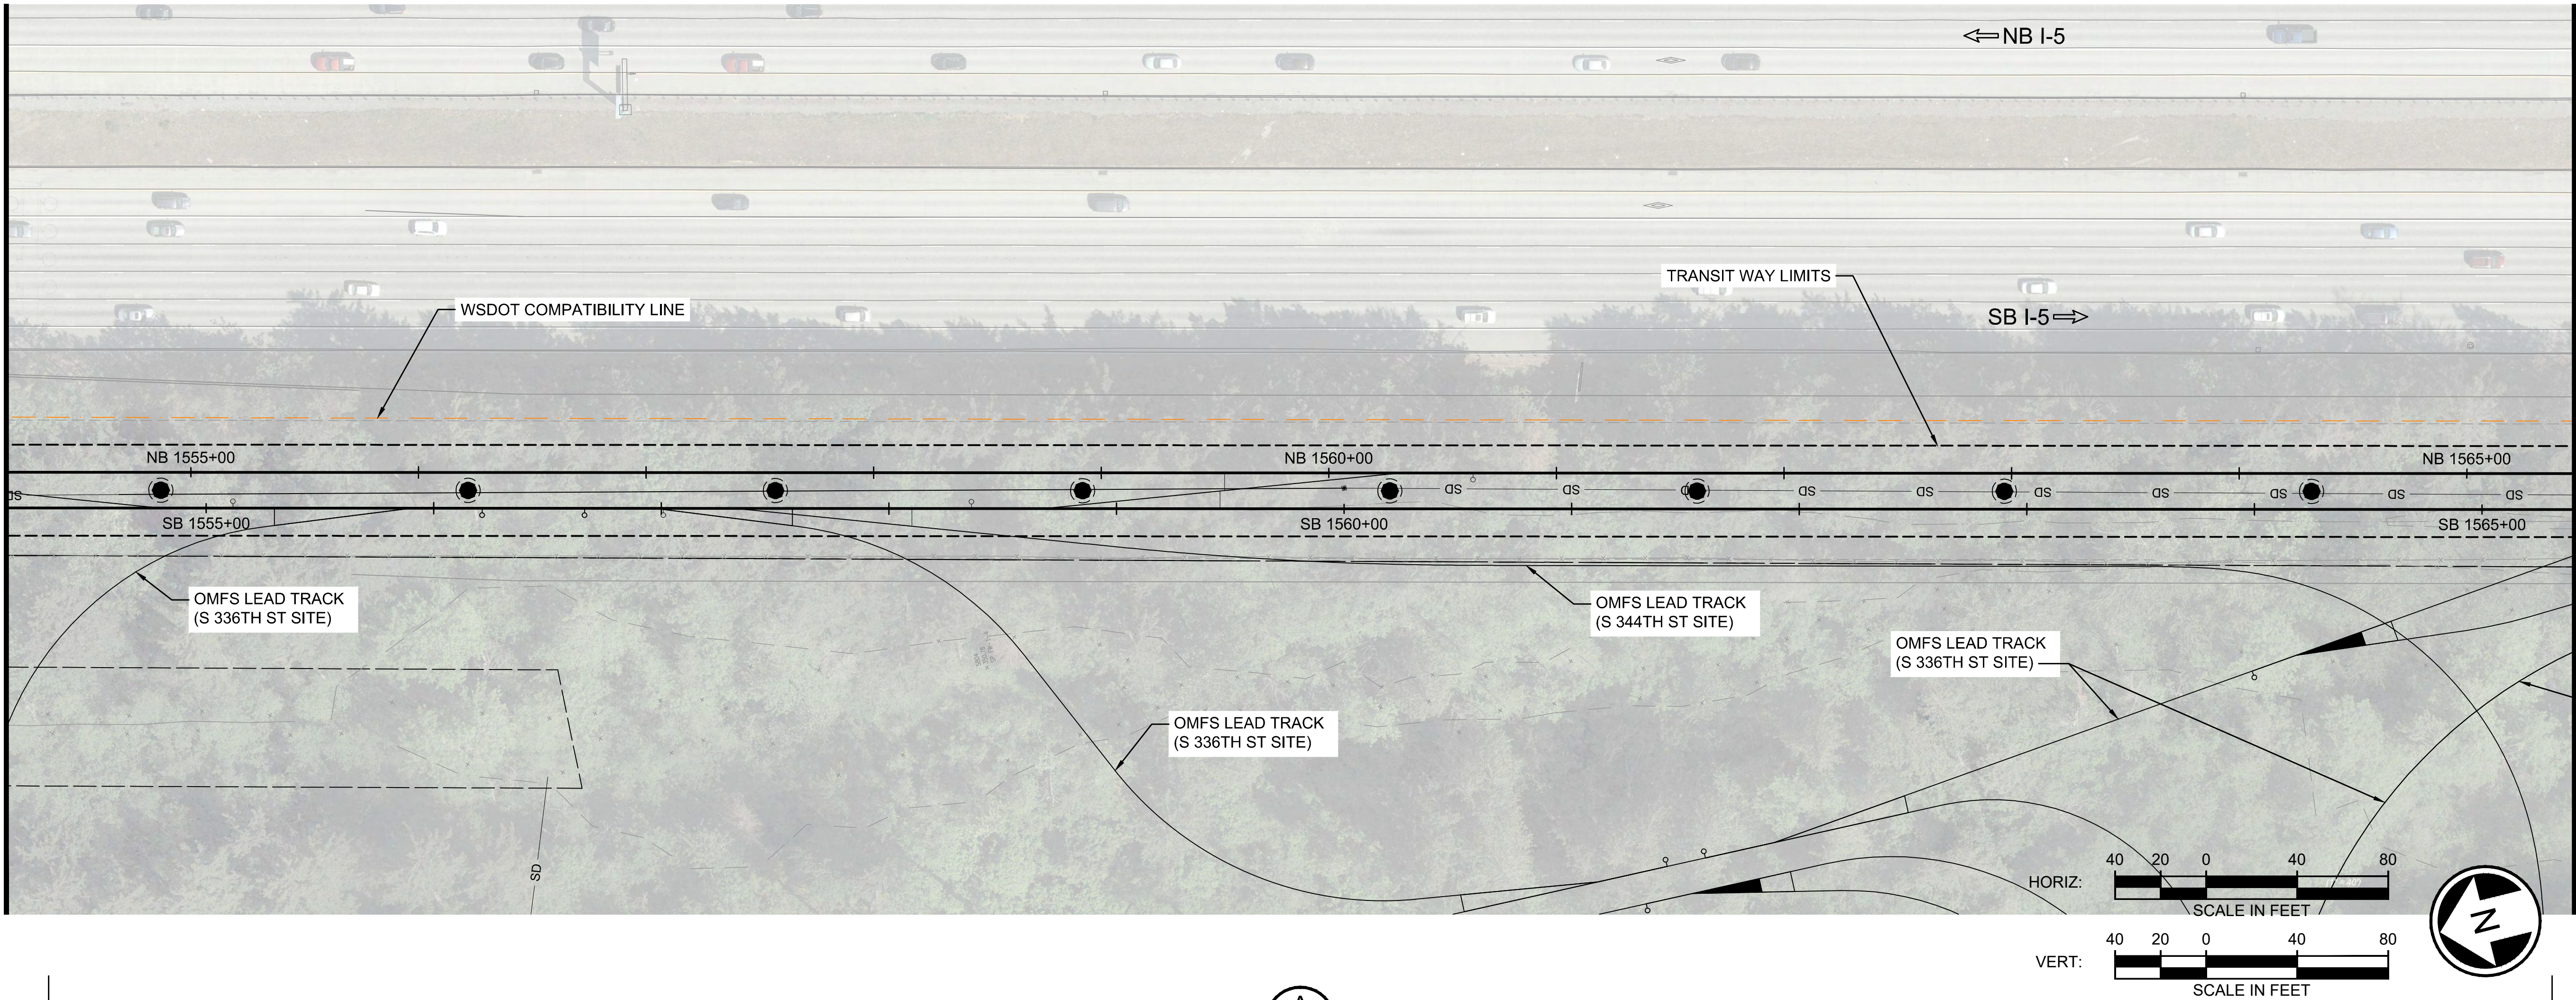

10% CONCEPTUAL ENGINEERING

No.	DATE	DSN	CHK	APP	REVISION

DESIGNED BY:
H. LIU
DRAWN BY:
J. TYLER
CHECKED BY:
M. PETERSON
APPROVED BY:
T. MUDAYANKAVIL

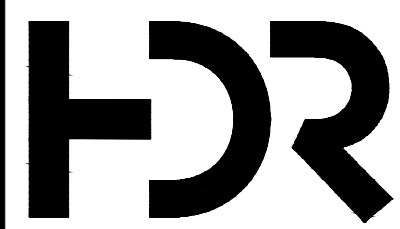

SUBMITTED BY:
THOMAS MUDAYANKAVIL

DATE:
MARCH 1, 2021

REVIEWED BY:

LINE IS 1" AT
FULL SCALE



DATE:
MARCH 1, 2021

SCALE:
1"=40'
FILENAME:
CONTRACT No.:
DATE:

SOUND TRANSIT
OPERATIONS & MAINTENANCE FACILITY SOUTH
CONCEPTUAL ENGINEERING
TDLE MAINLINE FOR OMFS
TRACK PLAN AND PROFILE
S FEDERAL WAY ENCHANTED PKWY

DRAWING No.:
S08A-KAP106
FACILITY ID:
SHEET No.:
REV:
17


CONCEPTUAL
ENGINEERING

NOT FOR
CONSTRUCTION



CONCEPTUAL
ENGINEERING


NOT FOR
CONSTRUCTION

SEE DWG S08A-KAP106

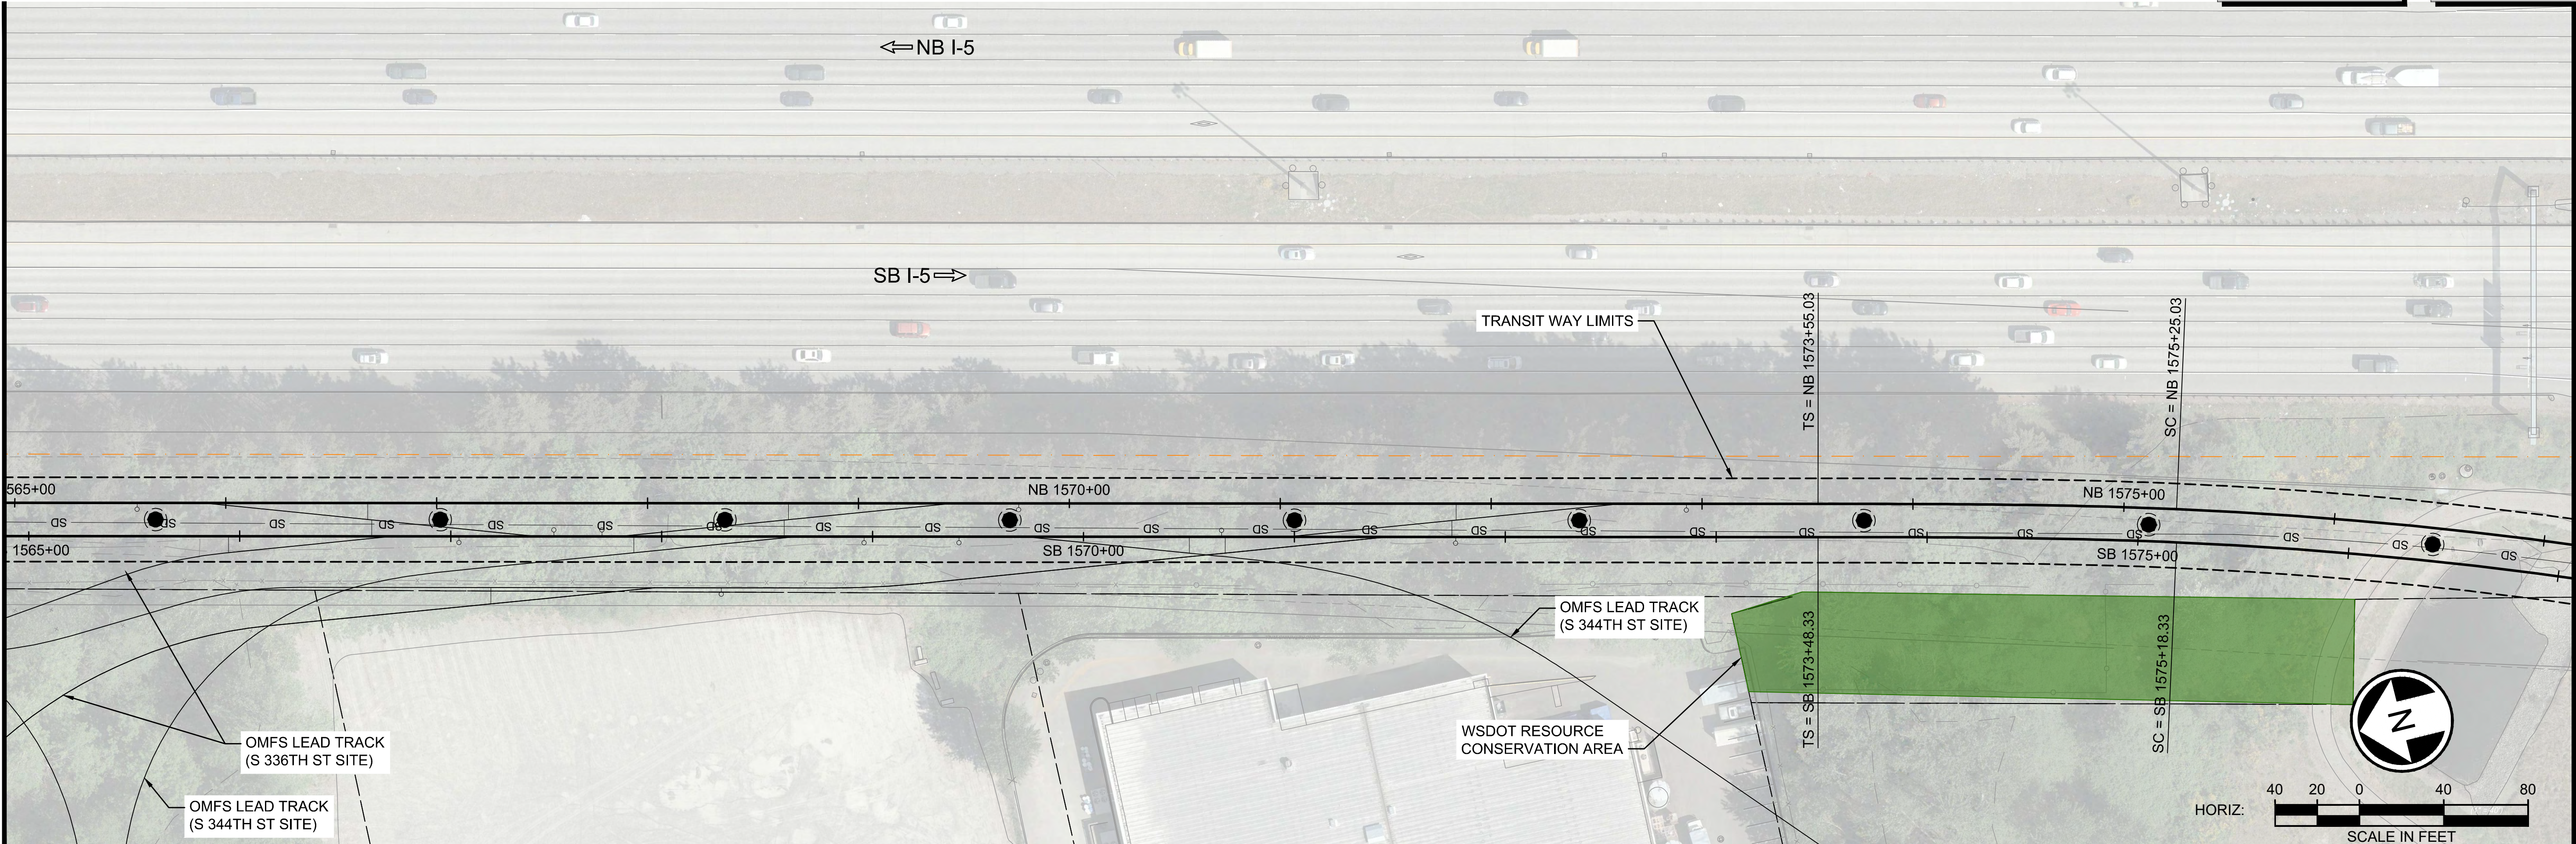

SEE DWG S08A-KAP108 FOR ENCHANTED PARKWAY ALIGNMENT
SEE DWG S08C-KAP201 FOR I-5 ALIGNMENT

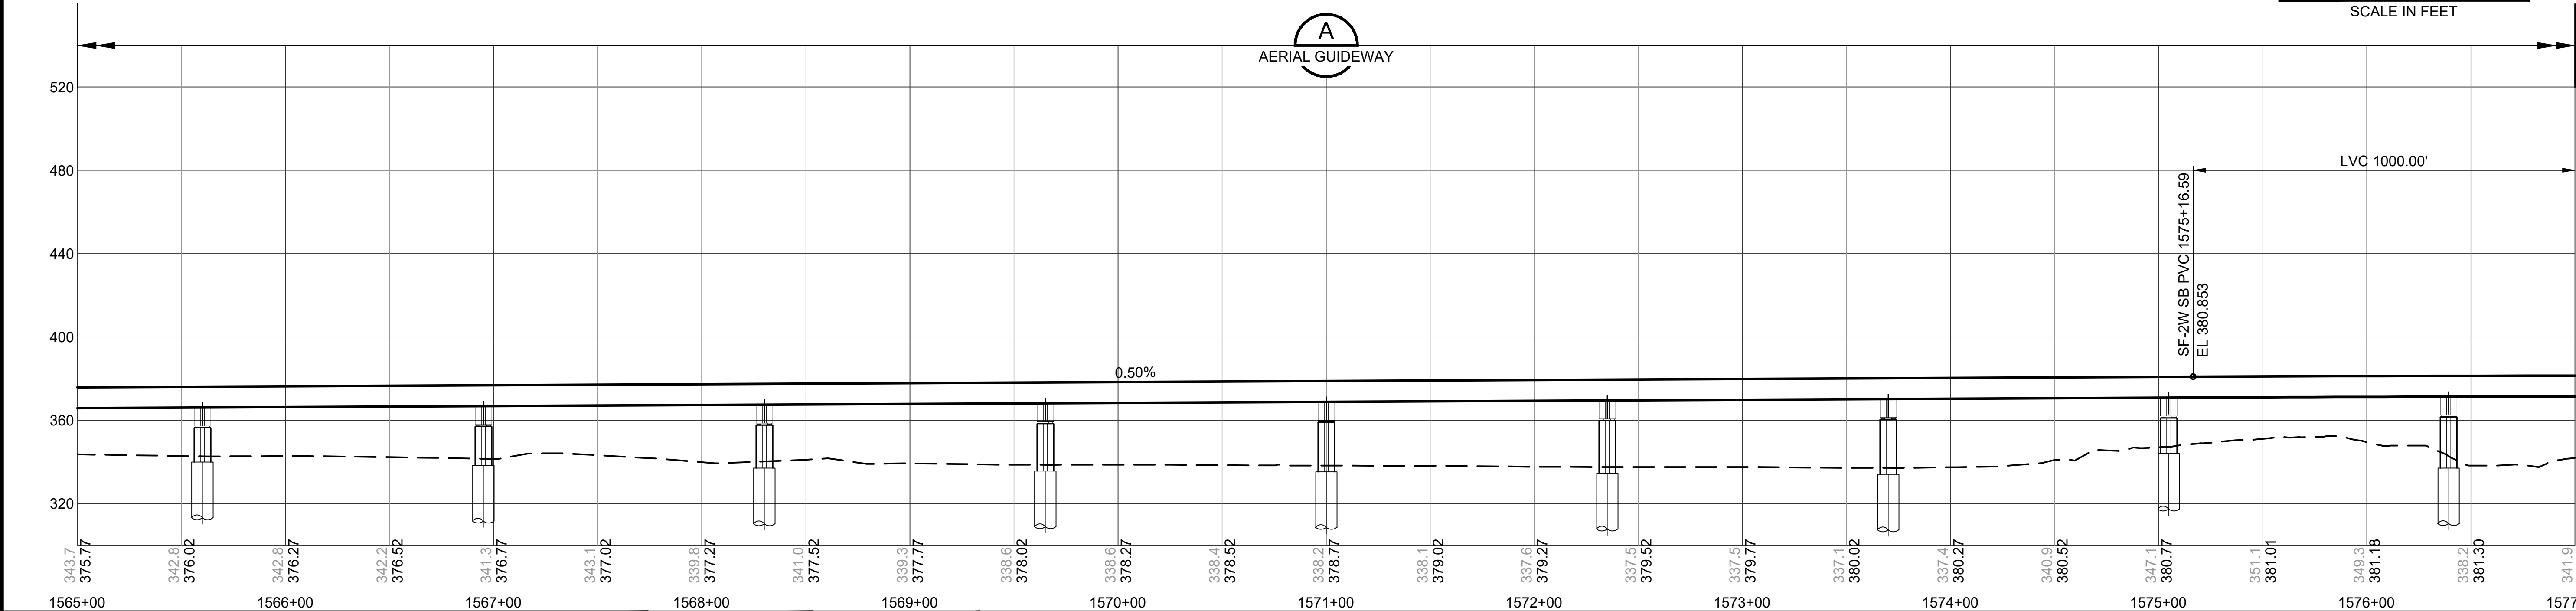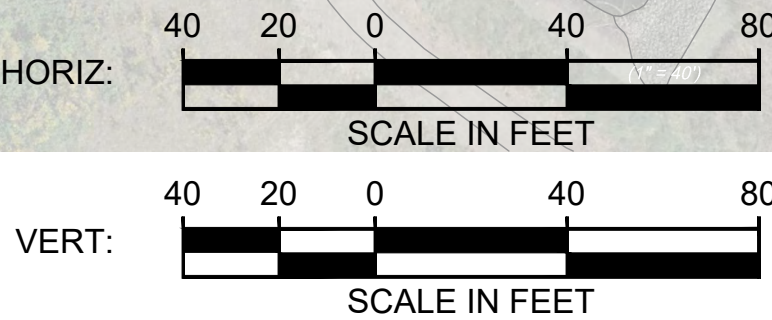

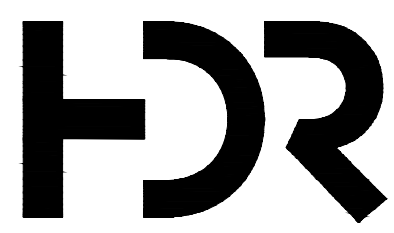10% CONCEPTUAL ENGINEERING						DESIGNED BY: H. LIU			SUBMITTED BY: THOMAS MUDAYANKAVIL	DATE: MARCH 1, 2021	REVIEWED BY:	DATE: MARCH 1, 2021		SCALE: 1"=40'	SOUND TRANSIT OPERATIONS & MAINTENANCE FACILITY SOUTH CONCEPTUAL ENGINEERING TDLE MAINLINE FOR OMFS TRACK PLAN AND PROFILE S FEDERAL WAY ENCHANTED PKWY	DRAWING No.: S08A-KAP107
						DRAWN BY: J. TYLER								FACILITY ID:		
						CHECKED BY: M. PETERSON								SHEET No.: 18		
						APPROVED BY: T. MUDAYANKAVIL								REV:		
No.	DATE	DSN	CHK	APP	REVISION											